


Notes:

SYMBOLS

-  ETC 36 DEGREE S4 375W
-  ETC 50 DEGREE S4 375W
-  ETC 70 DEGREE S4 375W
-  VELVET LIGHTS CYC4 80W
-  CREAMSOURCE SPACE X 1200W
-  CREAMSOURCE VORTEX 8 650W
-  CHAUVET COLORADO 1 SOLO 60W
-  CHAUVET COLORADO 2 SOLO 120W
-  ALTMAN MICRO-PAR 20 W/BARDOOR 15W
-  ALTMAN PAR 38 15W
-  ARYTON DIABLO S SPOT 300W
-  MAC AURA 260W
-  RGB WASHLIGHT
-  MASTER FX MYSTIC HAZER

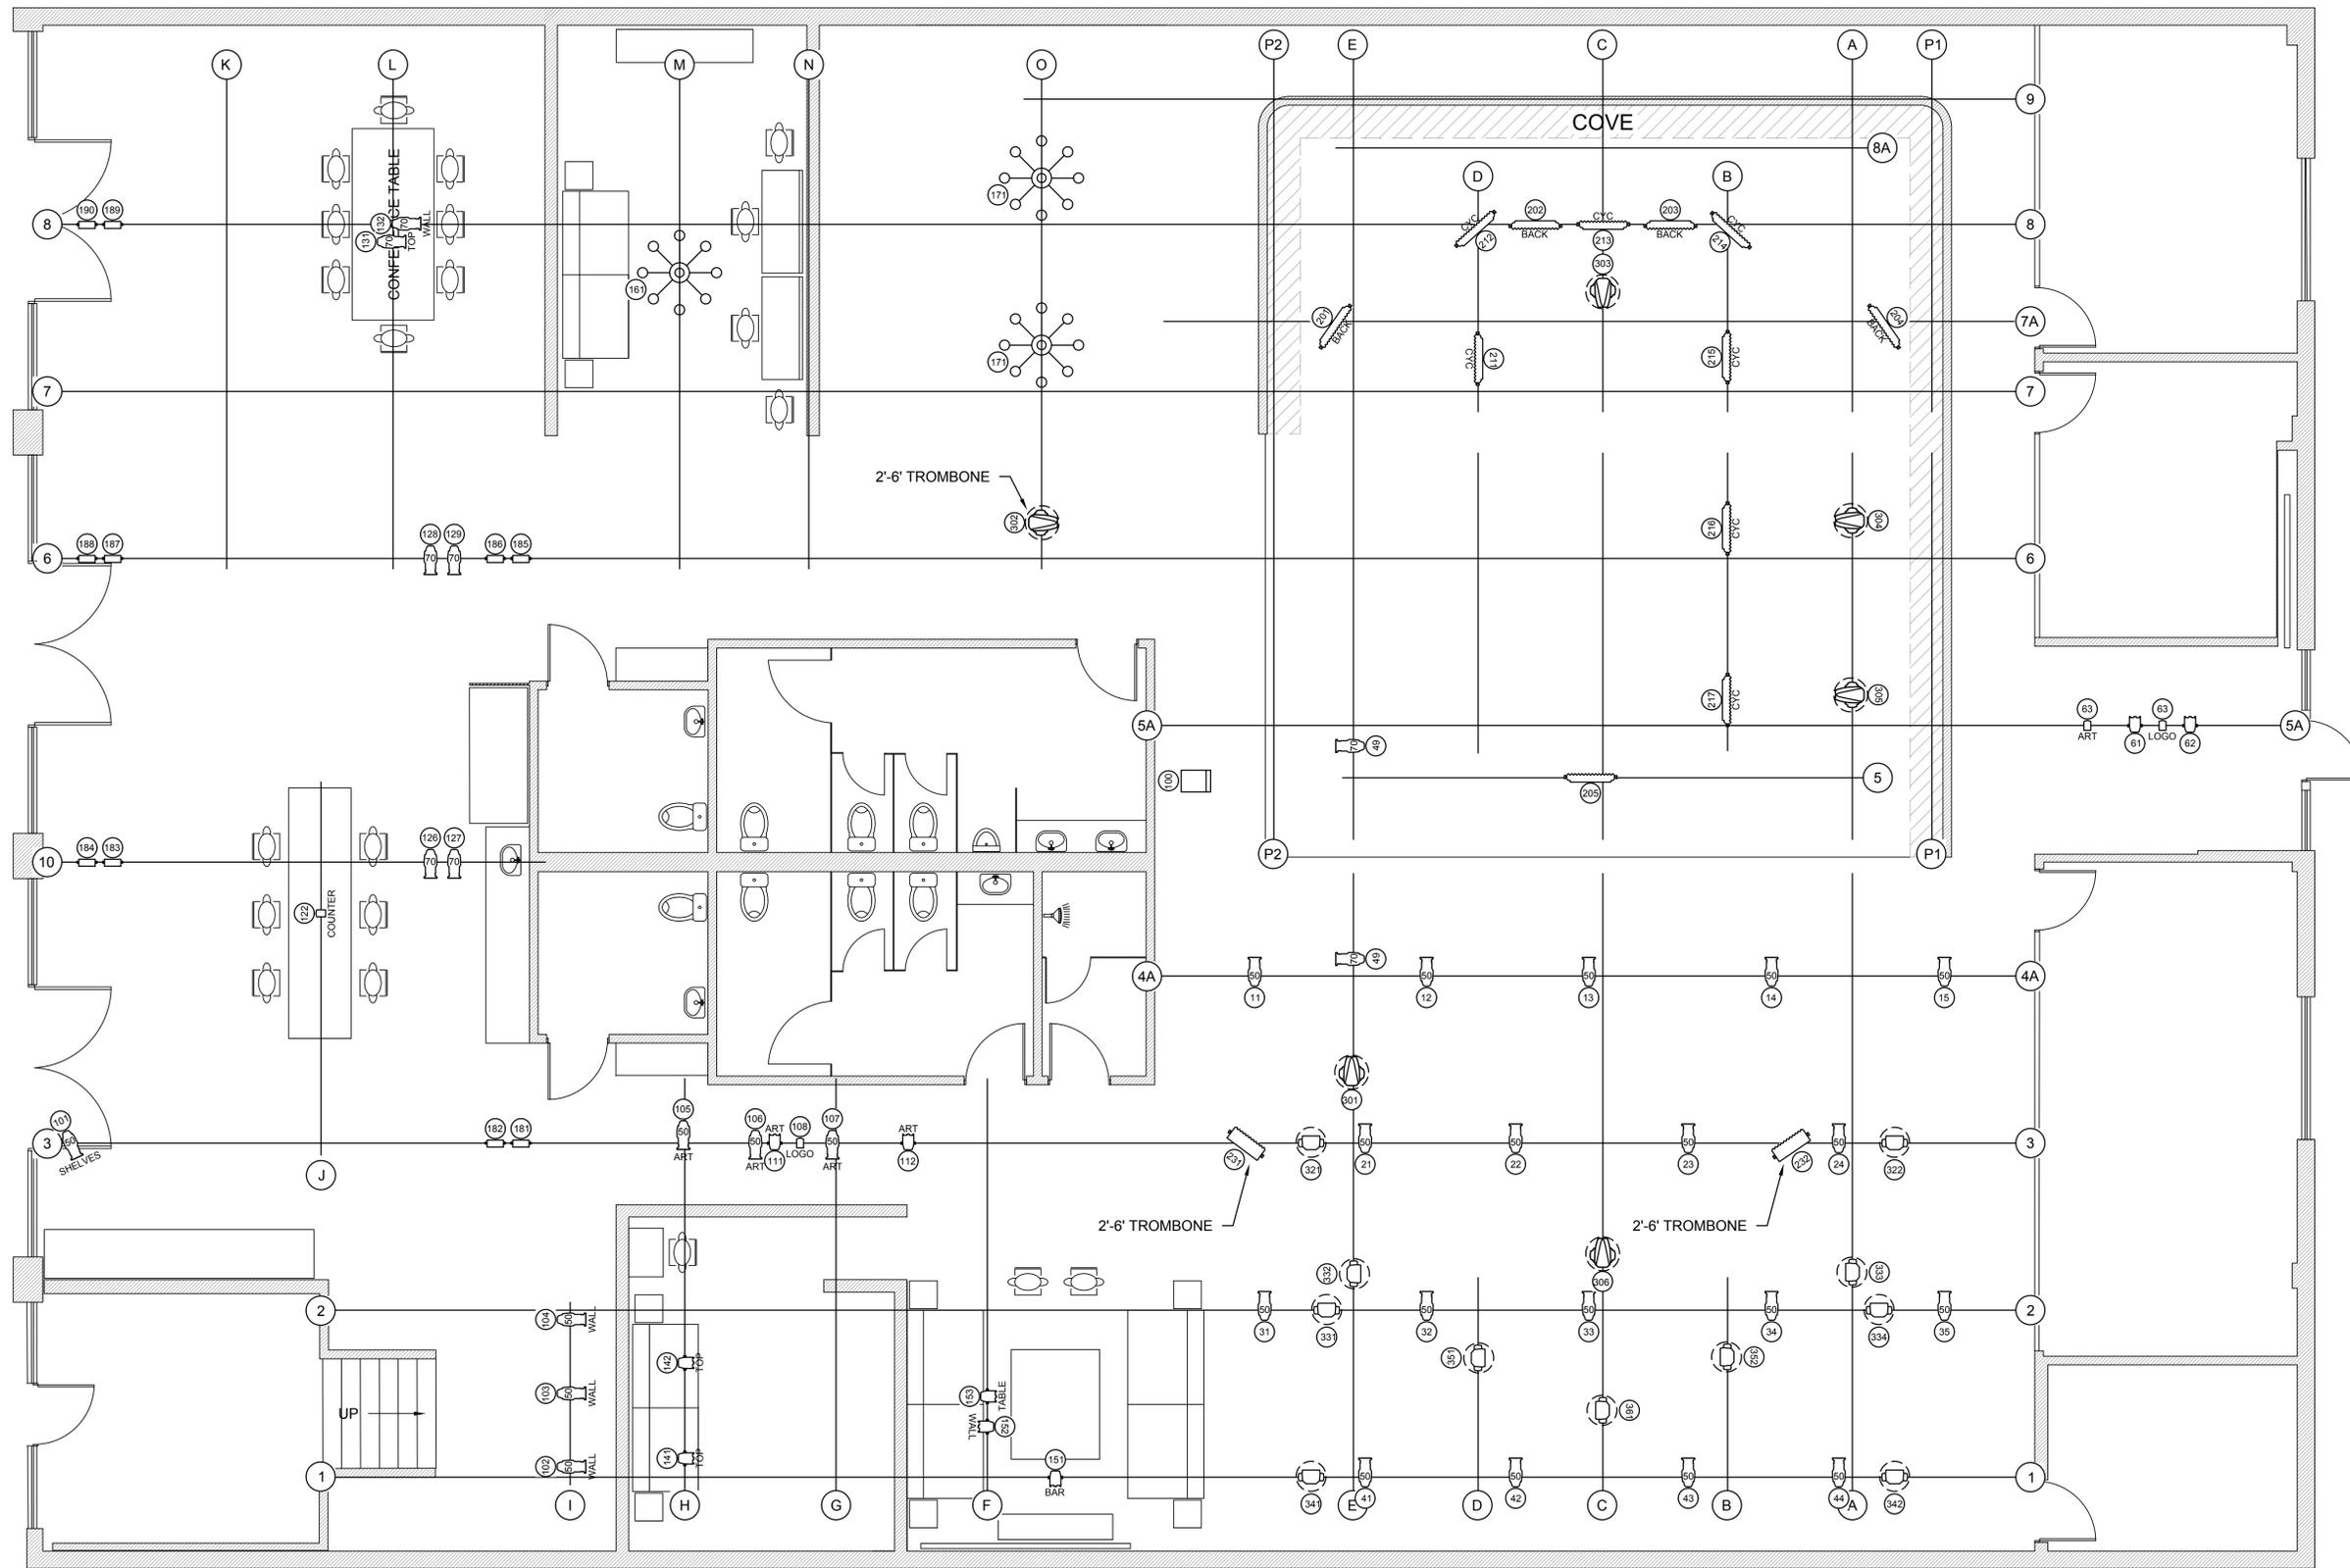

lulu
STUDIOS

1473 East 4th Street
Los Angeles, Ca 90033
hi@lulu.ar
+1 323-333-4270
lulu.ar

TITLE: LIGHTING PLAN			
SCALE: 1/4" = 1'-0"	DATE: 12/18/2025	DRAWN:	CHECKED:
PROJECT NO.:	DRAWING NO.:	REVISION:	Q