 


ABBREVIATIONS

AB	ABOVE COUNTER	HTR	HEATER	SCADA	SUPERVISORY CONTROL AND DATA ACQUISITION
AC	ALTERNATING CURRENT	HZ	HERTZ	SCCR	SHORT CIRCUIT CURRENT RATING
AF	AMPS FRAME	IP	CURRENT TO PRESSURE	SEC	SECONDARY
AFF	ABOVE FINISHED FLOOR	ID	INSIDE DIAMETER	SFS	SOFT START MOTOR STARTER
AFG	ABOVE FINISHED GRADE	ILPB	ILLUMINATED PUSHBUTTON	SP	SINGLE POLE
AHU	AIR HANDLING UNIT	IN	INCHES	SPD	SURGE PROTECTION DEVICE
AI	ANALOG INPUT	INSTR	INSTRUMENT	SS	SELECTOR SWITCH
AL	ALUMINUM	ISB	INTRINSIC SAFETY BARRIER	ST	SINGLE THROW
AM	AMMETER	JB	JUNCTION BOX OR PULL BOX	SV	SOLENOID VALVE
AO	ANALOG OUTPUT	KCMIL	THOUSANDS OF CIRCULAR MILS	SW	SWITCH
APPROX	APPROXIMATE	KIT	KITCHEN	SWGR	SWITCHGEAR
AT	AMPS TRIP	KS	KEY SWITCH	T	TRANSFORMER
ATS	AUTOMATIC TRANSFER SWITCH	KVA	KILOVOLT AMPERES	TB	TERMINAL BOARD
AUTO	AUTOMATIC	KVAR	KILOVOLT AMPERES REACTIVE	TD	TIME DELAY
AUX	AUXILIARY SWITCH	KW	KILOWATT	TEL	TELEPHONE TERMINAL
AV	AUDIO VISUAL	KWH	KILOWATT HOUR	Typ	TYPICAL
BESS	BATTERY ELECTRIC STORAGE SYSTEM	LA	LIGHTNING ARRESTOR	UH	UNIT HEATER
BFG	BELOW FINISHED GRADE	LC	LIGHTING CONTACTOR	UPS	UNINTERRUPTIBLE POWER SUPPLY
BLDG	BUILDING	LCP	LIGHTING CONTROL PANEL	V	VOLTS
BSMT	BASEMENT	LFMC	LIQUIDTIGHT FLEXIBLE METALLIC CONDUIT	VAC	VOLTS ALTERNATING CURRENT
C	CONDUIT	LI	LOAD INTERRUPTER	VDC	VOLTS DIRECT CURRENT
CAB	CABINET	LR	LINE OR LOAD REACTOR	VFD	VARIABLE FREQUENCY DRIVE
CB	CIRCUIT BREAKER	LTG	LIGHTING	VM	VOLT METER
CBL	CABLE	MA	MOTOR ALARM CONTACT	VT	VAPOR TIGHT
CKT	CIRCUIT	MAX	MAXIMUM	W	WATTS
CLG	CEILING	MC	METER CENTER	W	WIRE
CONC	CONCRETE	MCB	MOTOR BREAKER	W/	WITH
COOL	COOLING	MCC	MOTOR CONTROL CENTER	WELD	WELDING
CP	CONTROL PANEL	MCP	MOTOR CIRCUIT PROTECTOR	WHM	WATT HOUR METER
CPT	CONTROL POWER TRANSFORMER	MECH	MECHANICAL	WP	WEATHER PROOF
CR	CONTROL RELAY	MH	MANHOLE	XFMR	TRANSFORMER
CS	CONTROL STATION	MICR	MICROWAVE		
CT	CURRENT TRANSFORMER	MIN	MINIMUM		
CTR	COUNTER	MISC	MISCELLANEOUS		
CU	COPPER	MPZ	MINI POWER-ZONE		
DB	DISTRIBUTION BLOCK	MRS	MOTOR RATED SWITCH		
DC	DIRECT CURRENT	MS	MOTOR STARTER		
DI	DIGITAL INPUT	MSS	MOTOR STARTER SWITCH		
DIM	DIMENSION	MT	EMPTY		
DISP	DISPOSAL	MTR	MOTOR		
DIV	DIVISION	MTS	MANUAL TRANSFER SWITCH		
DN	DOWN	MV	MOTORIZED VALVE		
DO	DIGITAL OUTPUT	N	NEUTRAL		
DP	DISTRIBUTION PANEL	NC	NORMALLY CLOSED		
DS	DISCONNECT SWITCH	NF	NON-FUSED		
DT	DOUBLE THROW	NIC	NOT IN CONTRACT		
DWG	DRAWING	NO	NORMALLY OPEN		
EA	EACH	NON	NONCOINCIDENTAL		
ELECT	ELECTRICAL	NTS	NOT TO SCALE		
EPC	EMERGENCY PULL CORD	OC	ON CENTER		
EQUIP	EQUIPMENT	OD	OUTSIDE DIAMETER		
E-STOP	EMERGENCY STOP	OL	OVERLOAD RELAY		
ETM	ELAPSED TIME METER	OPG	OPENING		
EV	ELECTRIC VEHICLE	P	POLE		
EVSE	ELECTRIC VEHICLE SUPPLY EQUIPMENT	P/I	PRESSURE TO CURRENT		
EW	ELECTRIC WATER COOLER	PB	PUSH BUTTON		
F	FAN	PBS	PUSH BUTTON STATION		
FI	FAULT INTERRUPTER	PEC	PHOTO ELECTRIC CELL		
FLR	FLOOR	PER	PHOTO ELECTRIC RELAY		
FO	FIBER OPTIC CABLE	PH	PHASE		
FRACT	FRACTIONAL	PI	PULSE INPUT		
FT	FEET	PL	PILOT LIGHT		
FTP	FIBER TERMINATION PANEL	PLC	PROGRAMMABLE LOGIC CONTROLLER		
FU	FUSE	PM	POWER METER		
FVNR	FULL VOLTAGE NON-REVERSING	PO	PULSE OUTPUT		
FVR	FULL VOLTAGE REVERSING	POT	POTENTIOMETER		
G	GROUND, GROUNDED	PPE	PERSONAL PROTECTIVE EQUIPMENT		
GEN	GENERATOR	PRI	PRIMARY		
GFEP	GROUND FAULT EQUIPMENT PROTECTION	PVC	POLYVINYL CHLORIDE		
GFCI	GROUND FAULT CIRCUIT INTERRUPTER	PWS	POWER SUPPLY		
GND	GROUND	REC	RECEPTACLE		
HH	HAND HOLE	REFG	REFRIGERATOR		
HMI	HUMAN MACHINE INTERFACE	REQD	REQUIRED		
HOA	HAND-OFF-AUTO	RMC	RIGID METAL CONDUIT		
HP	HORSE POWER	RT	RAIN TIGHT		
HT	HEAT TRACE	RTD	RESISTANCE TEMPERATURE DETECTOR		
HTG	HEATING				

SYMBOLS

ITEMS SHOWN ON THIS SHEET ARE STANDARD SYMBOLS AND ABBREVIATIONS AND MAY NOT APPEAR ON THE PROJECT DRAWINGS	
GENERAL	LIGHTING
 NOTE, REFERRAL	 LUMINAIRE TYPE CIRCUIT NUMBER SWITCH IDENTIFICATION
 NOTE, REVISION	 LUMINAIRE ON EMERGENCY POWER INTEGRATED SENSOR
 CONDUIT <u>UNDERGROUND</u> OR <u>UNDERFLOOR</u>	 LUMINAIRE WITH WALL WASH OPTIC
 CONDUIT UP	 DOWNLIGHT
 CONDUIT DOWN	 2X4 LUMINAIRE
 CONDUIT STUB	 2X2 LUMINAIRE
 CONDUIT CONTINUED	 LINEAR CEILING MOUNT
 DEMOLISHED WORK	 LINEAR WALL MOUNT
 EXISTING TO REMAIN	 WALL-MOUNT LUMINAIRE
 NEW WORK	 TRACK LIGHT FIXTURE (QUANTITY OF HEADS AS SHOWN)
COMMUNICATION	 EXIT SIGN CEILING MOUNTED (ARROWS AND SHADING AS INDICATED)
 DATA JACK, WALL MOUNTED NUMBER BESIDE DATA JACK SYMBOL INDICATES NUMBER OF USED/USE OPENINGS AVAILABLE FOR DATA CONNECTIONS.	 EXIT SIGN WALL MOUNTED (ARROWS AND EMERGENCY HEADS AS INDICATED)
 DATA/VOICE JACK, WALL MOUNTED	 EMERGENCY FIXTURE
 VOICE ONLY JACK, WALL MOUNTED	 REMOTE HEADS FOR EMERGENCY FIXTURE
 TELEPHONE, WALL-MOUNTED	 BOLLARD/POST-TOP LUMINAIRE
 CEILING-MOUNTED DATA JACK	 POLE-MOUNT LUMINAIRE (QUANTITY OF HEADS AS SHOWN)
 WIRELESS ACCESS POINT, CEILING MOUNTED	 IN-GROUND FLOOD LIGHT
 COMMUNICATIONS FLOOR BOX, CONFIGURATION AS NOTED	 SWITCH, WALL MOUNTED
 TELEVISION JACK, WALL MOUNTED AT HEIGHT INDICATED	 SWITCH LEG
 MICROPHONE, CEILING MOUNTED	 SWITCH TYPE LV = LOW VOLTAGE D = DIMMER OS = OCCUPANCY SENSOR SWITCH VS = VACANCY SENSOR SWITCH 3 = 3-WAY PL = PILOT LIGHT SWITCH
 SPEAKER, CEILING MOUNTED	 CEILING MOUNTED SENSOR DS = DAYLIGHT SENSOR OS = OCCUPANCY SENSOR VS = VACANCY SENSOR
 SPEAKER, HORN TYPE CEILING MOUNTED	 WALL MOUNTED SENSOR DS = DAYLIGHT SENSOR OS = OCCUPANCY SENSOR VS = VACANCY SENSOR
 SPEAKER, WALL MOUNTED	 TIME CLOCK
 SPEAKER, HORN TYPE WALL MOUNTED	 LIGHTING CONTACTOR
 DATA CABINET WITH DOORS AS INDICATED	
 CABLE TRAY	
 CLOCK, WALL MOUNTED	
 BELL, WALL MOUNTED	
FIRE ALARM	
 BELL	
 DETECTOR, CEILING MOUNT S = SMOKE B = BEAM D = DUCT F = FIXED H = HEAT RR = RATE/RISE SD = SMOKE DAMPER	
 HORN, WALL MOUNTED	
 HORN STROBE, WALL MOUNTED (MIN CANDELA RATING AS INDICATED)	
 SPEAKER/STROBE, WALL MOUNTED (MIN CANDELA RATING AS INDICATED)	
 SPEAKER, WALL MOUNTED	
 STROBE, CEILING MOUNTED (MIN CANDELA RATING AS INDICATED)	
 HORN STROBE, CEILING MOUNTED (MIN CANDELA RATING AS INDICATED)	
 SPEAKER/STROBE, CEILING MOUNTED (MIN CANDELA RATING AS INDICATED)	
 INDIVIDUAL ADDRESSABLE MODULE	
 MAGNETIC DOOR HOLDER	
 MANUAL PULL STATION, WALL MOUNTED	
 RELAY	
 REMOTE TEST SWITCH	
 FLOW SWITCH, WALL MOUNTED	
 TAMPER SWITCH, WALL MOUNTED	
SECURITY	
 AUTOMATIC DOOR OPERATOR	
 BUZZER	
 CARD READER	
 CHIME	
 WALL-MOUNTED CAMERA (ARROW INDICATES AIMING DIRECTION)	
 CEILING-MOUNTED CAMERA (ARROW INDICATES AIMING DIRECTION)	
 DOOR CONTACTS	
 ELECTRIC STRIKE	
 GATE OPERATOR	
 HANDICAP DOOR PUSH-BUTTON	
 KEY PAD	
 MOTION DETECTOR/SENSOR	
 SECURITY SIREN	
 EMERGENCY PHONE, WALL-MOUNTED	
 REQUEST TO EXIT	
 ELECTRIFIED MORTISE LOCK	
 MAGNETIC LOCK	

Revision Schedule	Revision Title		Date
	Number	Revision Title	Date
A	100% DESIGN DEVELOPMENT		9/30/26

100% DESIGN DEVELOPMENT
NOT FOR CONSTRUCTION

RAMBLER BATON ROUGE

BURBANK DR.
BATON ROUGE, LA

Project Number 26078
Date 09/30/26
Technician BKS
Superintendent WAW
Project Manager SS

LEVEL 2 WEST POWER PLAN

Sheet Number


E111

9/30/2026 2:12:29 PM

120/208V	SEC 1	SEC 2	SEC 3	SEC 4	SEC 3	SEC 2	SEC 1	277/480V
BLACK	1	43	85	127	128	86	44	2 BROWN
RED	3	45	87	129	130	88	46	4 ORANGE
BLUE	5	47	89	131	132	90	48	6 YELLOW
BLACK	7	49	91	133	134	92	50	8 BROWN
RED	9	51	93	135	136	94	52	10 ORANGE
BLUE	11	53	95	137	138	96	54	12 YELLOW
BLACK	13	55	97	139	140	98	56	14 BROWN
RED	15	57	99	141	142	100	58	16 ORANGE
BLUE	17	59	101	143	144	102	60	18 YELLOW
BLACK	19	61	103	145	146	104	62	20 BROWN
RED	21	63	105	147	148	106	64	22 ORANGE
BLUE	23	65	107	149	150	108	66	24 YELLOW
BLACK	25	67	109	151	152	110	68	26 BROWN
RED	27	69	111	153	154	112	70	28 ORANGE
BLUE	29	71	113	155	156	114	72	30 YELLOW
BLACK	31	73	115	157	158	116	74	32 BROWN
RED	33	75	117	159	160	118	76	34 ORANGE
BLUE	35	77	119	161	162	120	78	36 YELLOW
BLACK	37	79	121	163	164	122	80	38 BROWN
RED	39	81	123	165	166	124	82	40 ORANGE
BLUE	41	83	125	167	168	126	84	42 YELLOW

GENERAL NOTES

- REFER TO SHEET E000 FOR ADDITIONAL GENERAL NOTES.
- ALL WIRING SHALL BE INSTALLED IN CONDUIT UNLESS NOTED OTHERWISE.
- ALL BRANCH CIRCUIT WIRING TO BE THIN INDOORS, AND XHHW-2 OUTDOORS (INCLUDING ON ROOF), UNLESS OTHERWISE NOTED.
- ALL BRANCH CIRCUITS TO INCLUDE GREEN EQUIPMENT GROUND.
- NO SHARED NEUTRALS. EACH NEUTRAL MUST BE IDENTIFIED FOR ITS PHASE.
- ALL RECEPTACLES IN WET LOCATIONS, WITHIN 6' OF A SINK OR OUTDOORS TO BE GFCI.

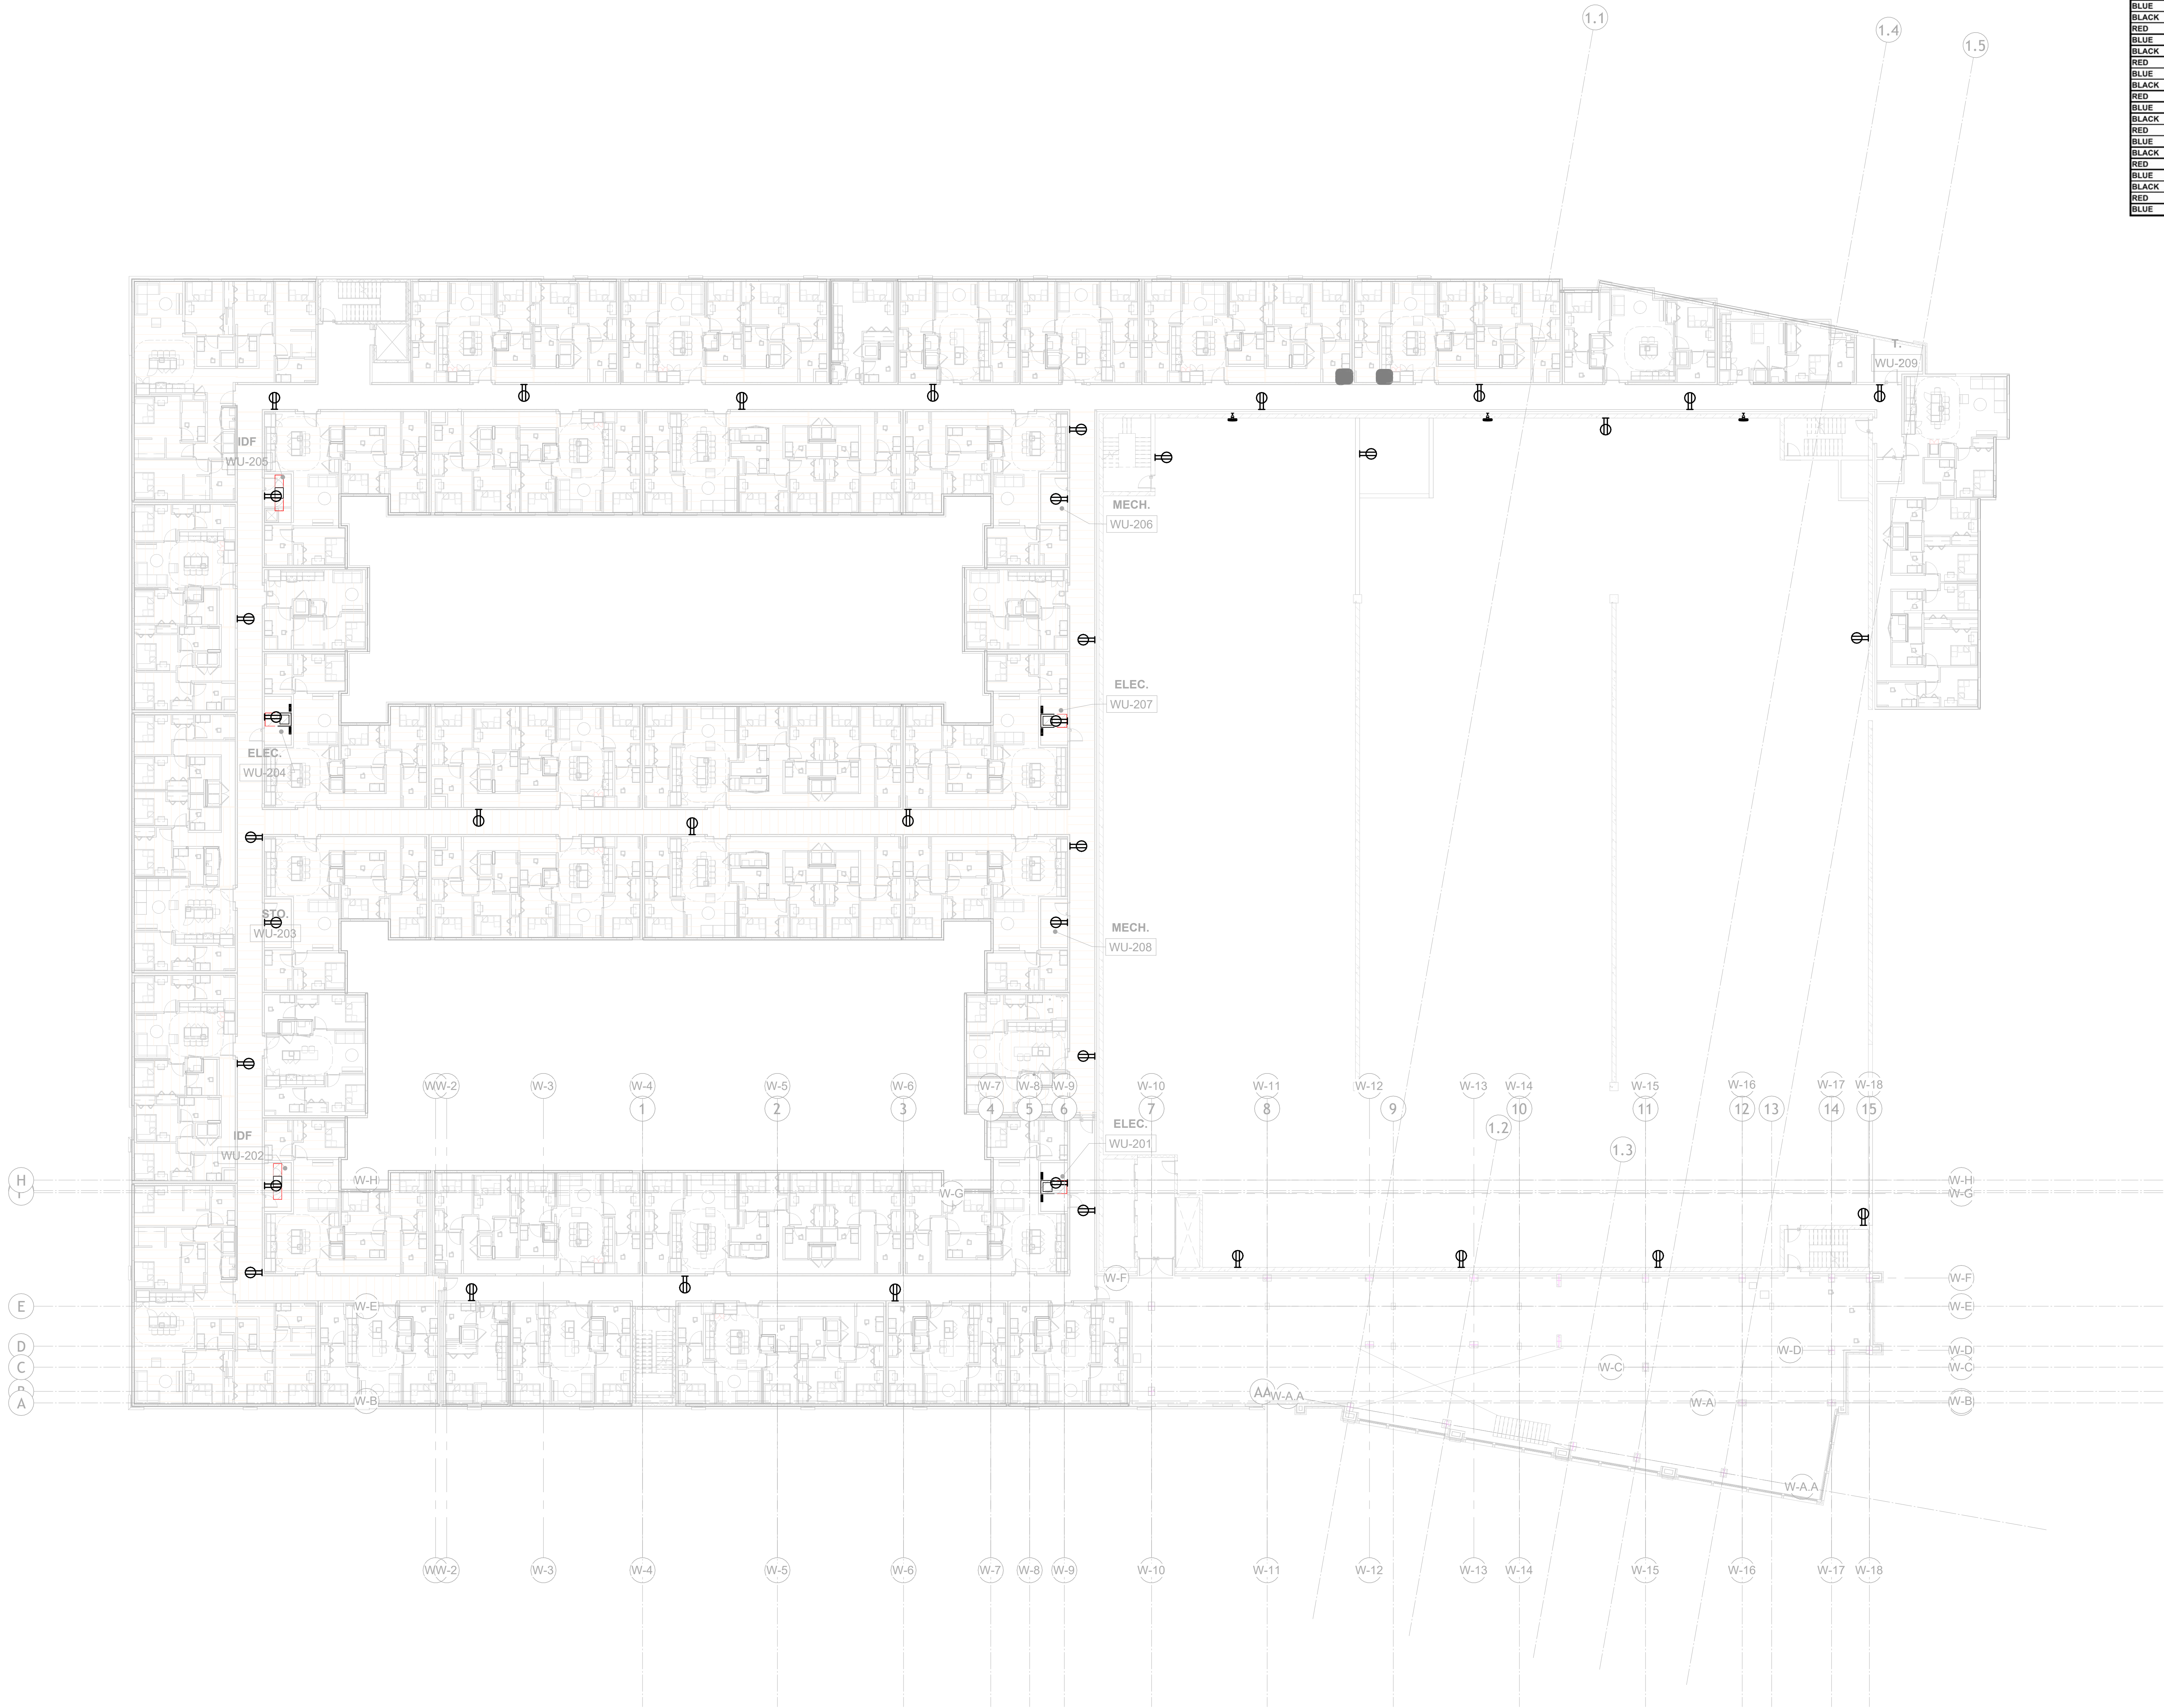

1 LEVEL 2 WEST POWER PLAN
1/16" = 1'-0"

120/208V	SEC 1	SEC 2	SEC 3	SEC 4	SEC 3	SEC 2	SEC 1	277/480V
BLACK	1	43	85	127	128	86	44	2 BROWN
RED	3	45	87	129	130	88	46	4 ORANGE
BLUE	5	47	89	131	132	90	48	6 YELLOW
BLACK	7	49	91	133	134	92	50	8 BROWN
RED	9	51	93	135	136	94	52	10 ORANGE
BLUE	11	53	95	137	138	96	54	12 YELLOW
BLACK	13	55	97	139	140	98	56	14 BROWN
RED	15	57	99	141	142	100	58	16 ORANGE
BLUE	17	59	101	143	144	102	60	18 YELLOW
BLACK	19	61	103	145	146	104	62	20 BROWN
RED	21	63	105	147	148	106	64	22 ORANGE
BLUE	23	65	107	149	150	108	66	24 YELLOW
BLACK	25	67	109	151	152	110	68	26 BROWN
RED	27	69	111	153	154	112	70	28 ORANGE
BLUE	29	71	113	155	156	114	72	30 YELLOW
BLACK	31	73	115	157	158	116	74	32 BROWN
RED	33	75	117	159	160	118	76	34 ORANGE
BLUE	35	77	119	161	162	120	78	36 YELLOW
BLACK	37	79	121	163	164	122	80	38 BROWN
RED	39	81	123	165	166	124	82	40 ORANGE
BLUE	41	83	125	167	168	126	84	42 YELLOW



https://www.HaysElectrical.Com


THIS PRINT IS THE PROPERTY OF HAYS ELECTRICAL SERVICES. IT MUST NOT BE REPRODUCED IN ANY MANNER NOR SHALL IT BE SUBMITTED TO OUTSIDE PARTIES FOR EXAMINATION WITHOUT OUR CONSENT. IT SHALL BE USED ONLY AS A REFERENCE TO WORK DESIGNED OR FURNISHED BY US.

Project General Notes:
1. Reuse layout as needed base on SPECS/E.E.C. requirement.
2. Installed Junction Box at accessible location for future service access.
3.
4.



GENERAL NOTES

- REFER TO SHEET E000 FOR ADDITIONAL GENERAL NOTES.
- ALL WIRING SHALL BE INSTALLED IN CONDUIT UNLESS NOTED OTHERWISE.
- ALL BRANCH CIRCUIT WIRING TO BE THIN INDOORS, AND XHHW-2 OUTDOORS (INCLUDING ON ROOF), UNLESS OTHERWISE NOTED.
- ALL BRANCH CIRCUITS TO INCLUDE GREEN EQUIPMENT GROUND.
- NO SHARED NEUTRALS. EACH NEUTRAL MUST BE IDENTIFIED FOR ITS PHASE.
- ALL RECEPTACLES IN WET LOCATIONS, WITHIN 6' OF A SINK OR OUTDOORS TO BE GFCI.

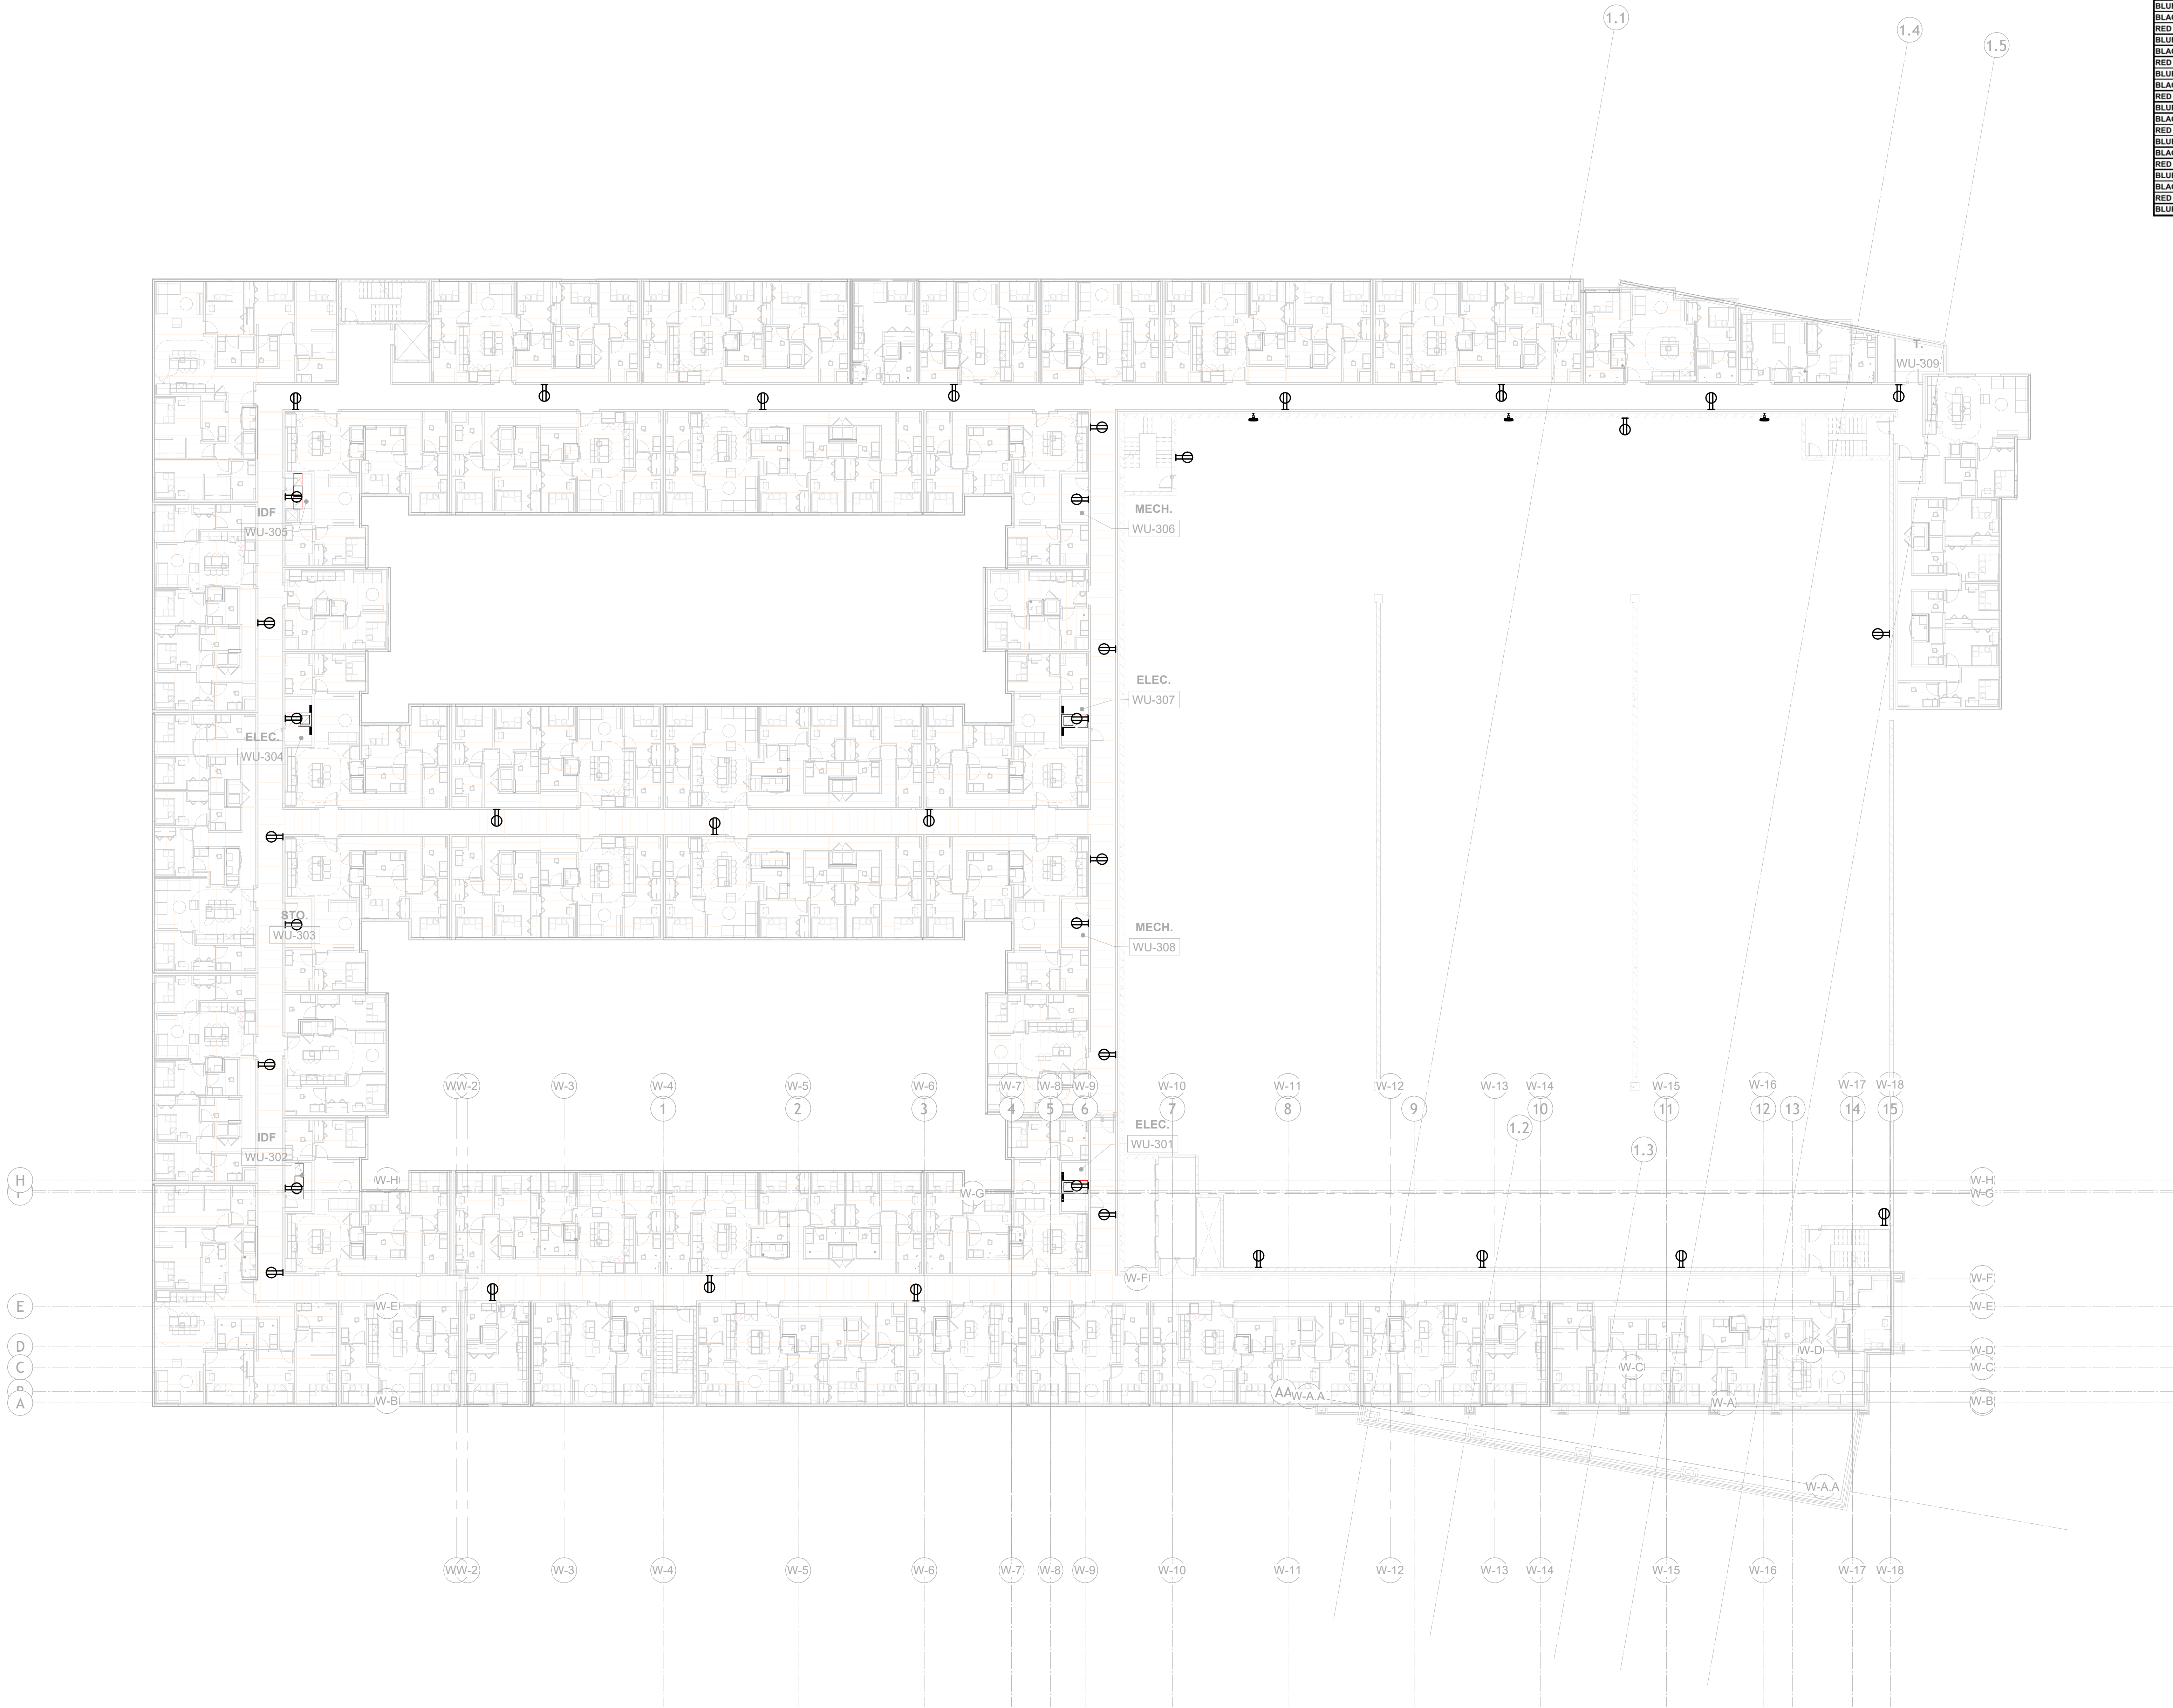

1 LEVEL 3 WEST POWER PLAN
E112 1/16" = 1'-0"

100% DESIGN DEVELOPMENT
NOT FOR CONSTRUCTION

RAMBLER BATON ROUGE

BURBANK DR.
BATON ROUGE, LA

Project Number 26078
Date 09/30/26
Technician BKS
Superintendent WAW
Project Manager SS

LEVEL 3 WEST POWER
PLAN

Sheet Number

E112

120/208V	SEC 1	SEC 2	SEC 3	SEC 4	SEC 4	SEC 3	SEC 2	SEC 1	277/480V
BLACK	1	43	85	127	128	86	44	2	BROWN
RED	3	45	87	129	130	88	46	4	ORANGE
BLUE	5	47	89	131	132	90	48	6	YELLOW
BLACK	7	49	91	133	134	92	50	8	BROWN
RED	9	51	93	135	136	94	52	10	ORANGE
BLUE	11	53	95	137	138	96	54	12	YELLOW
BLACK	13	55	97	139	140	98	56	14	BROWN
RED	15	57	99	141	142	100	58	16	ORANGE
BLUE	17	59	101	143	144	102	60	18	YELLOW
BLACK	19	61	103	145	146	104	62	20	BROWN
RED	21	63	105	147	148	106	64	22	ORANGE
BLUE	23	65	107	149	150	108	66	24	YELLOW
BLACK	25	67	109	151	152	110	68	26	BROWN
RED	27	69	111	153	154	112	70	28	ORANGE
BLUE	29	71	113	155	156	114	72	30	YELLOW
BLACK	31	73	115	157	158	116	74	32	BROWN
RED	33	75	117	159	160	118	76	34	ORANGE
BLUE	35	77	119	161	162	120	78	36	YELLOW
BLACK	37	79	121	163	164	122	80	38	BROWN
RED	39	81	123	165	166	124	82	40	ORANGE
BLUE	41	83	125	167	168	126	84	42	YELLOW



https://www.HaysElectrical.Com

THIS PRINT IS THE PROPERTY OF HAYS ELECTRICAL SERVICES. IT MUST NOT BE REPRODUCED IN ANY MANNER NOR SHALL IT BE SUBMITTED TO OUTSIDE PARTIES FOR EXAMINATION WITHOUT OUR CONSENT. IT SHALL BE USED ONLY AS A REFERENCE TO WORK DESIGNED OR FURNISHED BY US.

Project General Notes:
1. Rense layout as needed base on SPECS/E.C. requirement
2. Installed Junction Box at accessible location for future service access.
3.
4.



Revision Schedule		Date
Number	Revision Title	
A	100% DESIGN DEVELOPMENT	9/30/26

100% DESIGN DEVELOPMENT
NOT FOR CONSTRUCTION

RAMBLER BATON ROUGE

BURBANK DR.
BATON ROUGE, LA


Project Number 26078
Date 09/30/26
Technician BKS
Superintendent WAW
Project Manager SS

LEVEL 4 WEST POWER
PLAN

Sheet Number

E113

9/30/2026 2:12:53 PM

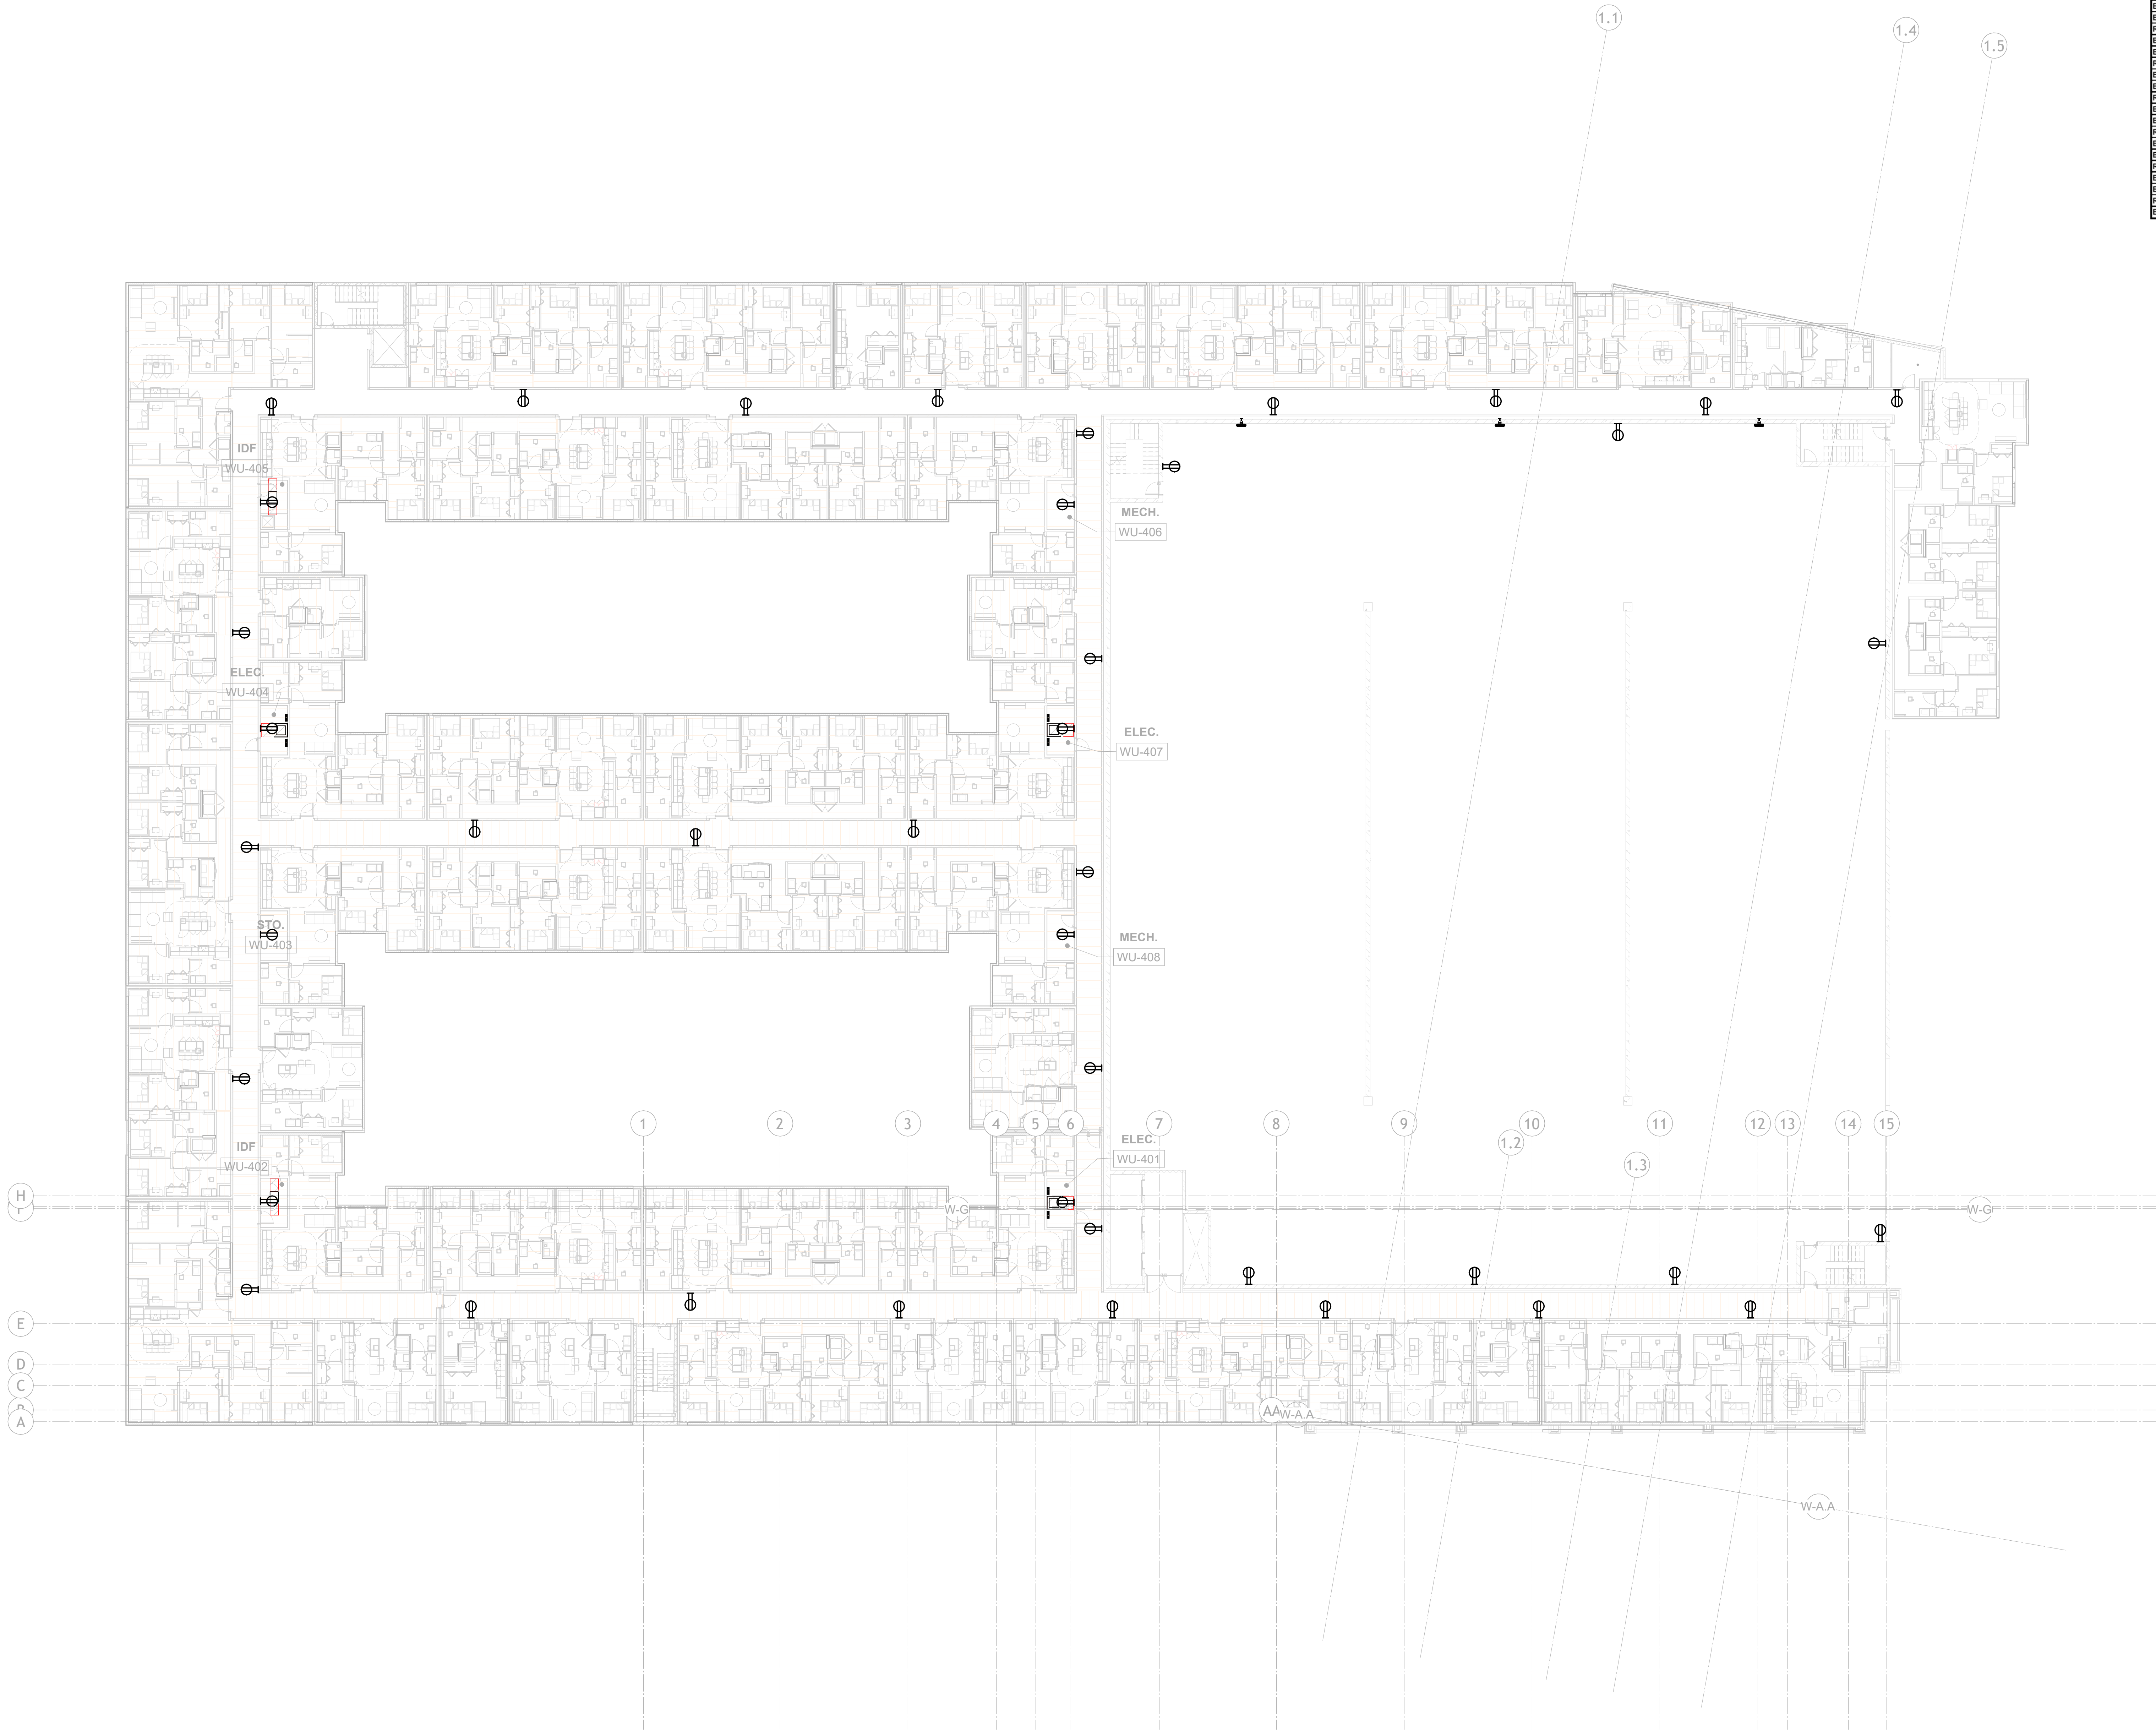

1 LEVEL 4 WEST POWER PLAN
E113 1/16" = 1'-0"

120/208V	SEC 1	SEC 2	SEC 3	SEC 4	SEC 3	SEC 2	SEC 1	277/480V
BLACK	1	43	85	127	128	86	44	2 BROWN
RED	3	45	87	129	130	88	46	4 ORANGE
BLUE	5	47	89	131	132	90	48	6 YELLOW
BLACK	7	49	91	133	134	92	50	8 BROWN
RED	9	51	93	135	136	94	52	10 ORANGE
BLUE	11	53	95	137	138	96	54	12 YELLOW
BLACK	13	55	97	139	140	98	56	14 BROWN
RED	15	57	99	141	142	100	58	16 ORANGE
BLUE	17	59	101	143	144	102	60	18 YELLOW
BLACK	19	61	103	145	146	104	62	20 BROWN
RED	21	63	105	147	148	106	64	22 ORANGE
BLUE	23	65	107	149	150	108	66	24 YELLOW
BLACK	25	67	109	151	152	110	68	26 BROWN
RED	27	69	111	153	154	112	70	28 ORANGE
BLUE	29	71	113	155	156	114	72	30 YELLOW
BLACK	31	73	115	157	158	116	74	32 BROWN
RED	33	75	117	159	160	118	76	34 ORANGE
BLUE	35	77	119	161	162	120	78	36 YELLOW
BLACK	37	79	121	163	164	122	80	38 BROWN
RED	39	81	123	165	166	124	82	40 ORANGE
BLUE	41	83	125	167	168	126	84	42 YELLOW



https://www.HaysElectrical.Com

THIS PRINT IS THE PROPERTY OF HAYS ELECTRICAL SERVICES. IT MUST NOT BE REPRODUCED IN ANY MANNER NOR SHALL IT BE SUBMITTED TO OUTSIDE PARTIES FOR EXAMINATION WITHOUT OUR CONSENT. IT SHALL BE USED ONLY AS A REFERENCE TO WORK DESIGNED OR FURNISHED BY US.

Project General Notes:
1. Reuse layout as needed base on SPECS/E.C. requirement.
2. Installed Junction Box at accessible location for future service access.
3.
4.



Revision Schedule	Revision Title		Date
	Number	Revision Title	Date
A	100% DESIGN DEVELOPMENT		9/30/26

100% DESIGN DEVELOPMENT
NOT FOR CONSTRUCTION

RAMBLER BATON ROUGE

BURBANK DR.
BATON ROUGE, LA


Project Number 26078
Date 09/30/26
Technician BKS
Superintendent WAW
Project Manager SS

LEVEL 5 WEST POWER PLAN

Sheet Number

E114

9/30/2026 2:13:05 PM

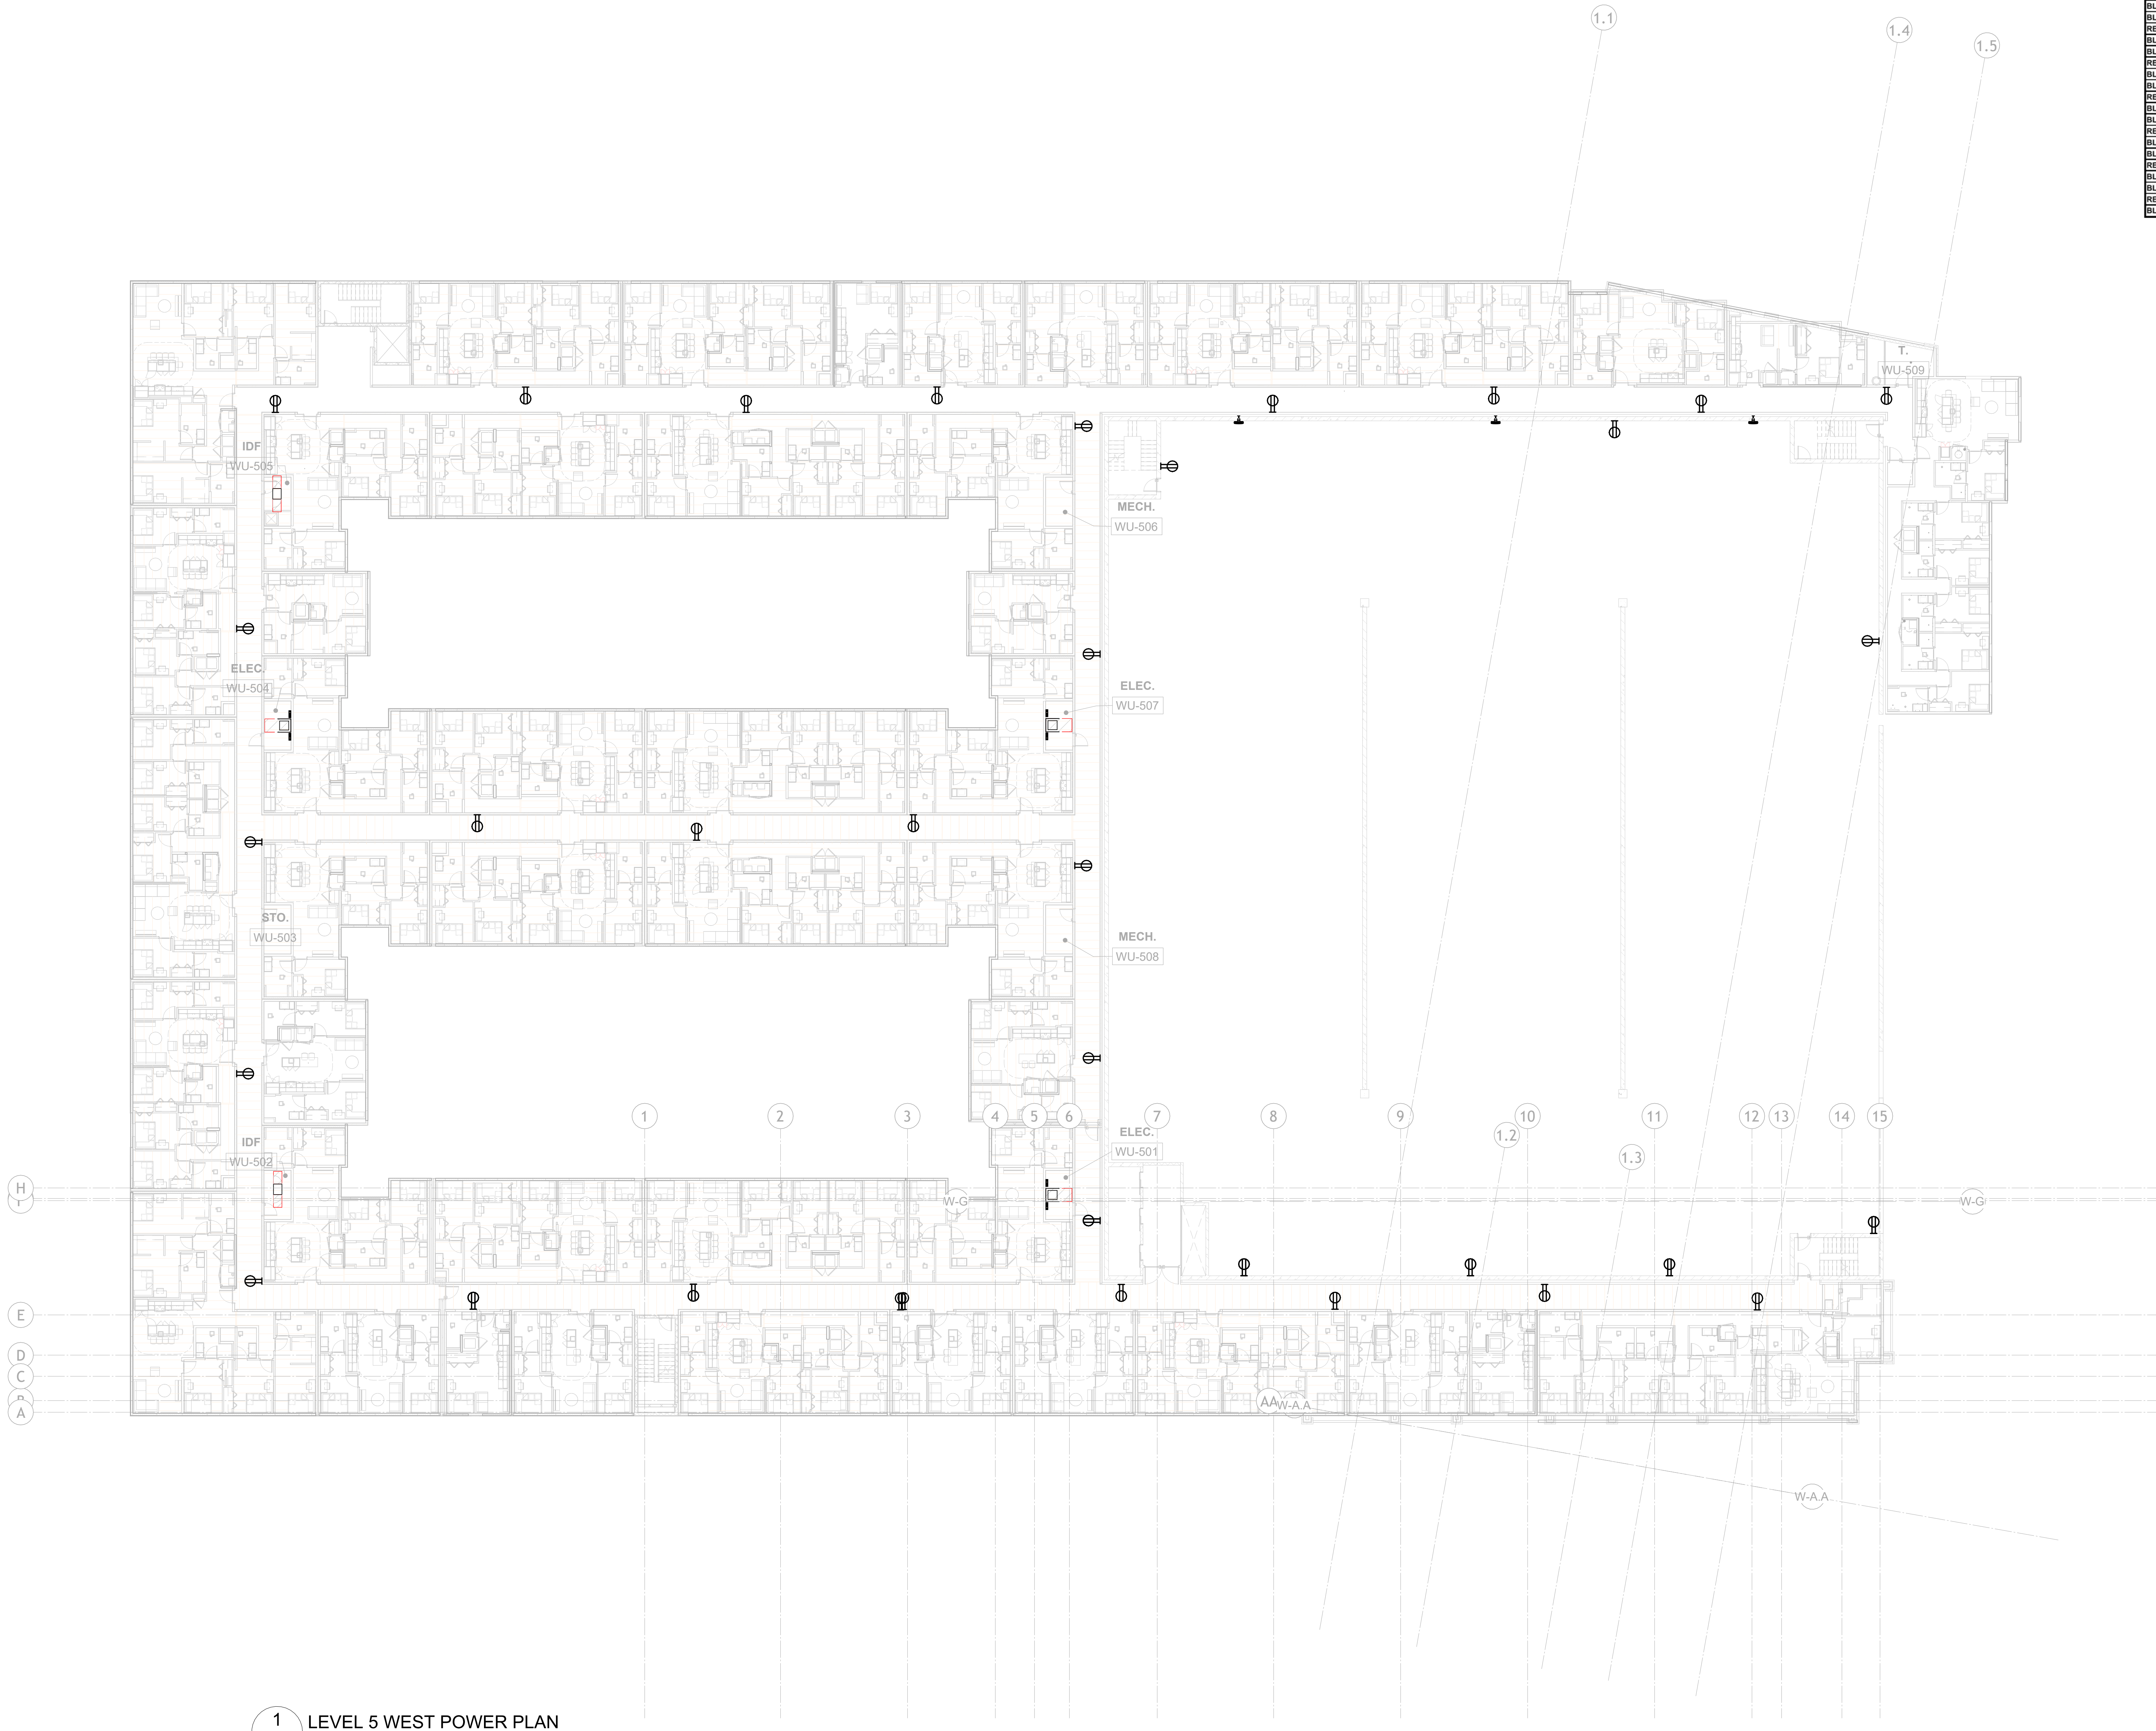

1 LEVEL 5 WEST POWER PLAN
E114 1/16" = 1'-0"

120/208V	SEC 1	SEC 2	SEC 3	SEC 4	SEC 4	SEC 3	SEC 2	SEC 1	277/480V
BLACK	1	43	85	127	128	86	44	2	BROWN
RED	3	45	87	129	130	88	46	4	ORANGE
BLUE	5	47	89	131	132	90	48	6	YELLOW
BLACK	7	49	91	133	134	92	50	8	BROWN
RED	9	51	93	135	136	94	52	10	ORANGE
BLUE	11	53	95	137	138	96	54	12	YELLOW
BLACK	13	55	97	139	140	98	56	14	BROWN
RED	15	57	99	141	142	100	58	16	ORANGE
BLUE	17	59	101	143	144	102	60	18	YELLOW
BLACK	19	61	103	145	146	104	62	20	BROWN
RED	21	63	105	147	148	106	64	22	ORANGE
BLUE	23	65	107	149	150	108	66	24	YELLOW
BLACK	25	67	109	151	152	110	68	26	BROWN
RED	27	69	111	153	154	112	70	28	ORANGE
BLUE	29	71	113	155	156	114	72	30	YELLOW
BLACK	31	73	115	157	158	116	74	32	BROWN
RED	33	75	117	159	160	118	76	34	ORANGE
BLUE	35	77	119	161	162	120	78	36	YELLOW
BLACK	37	79	121	163	164	122	80	38	BROWN
RED	39	81	123	165	166	124	82	40	ORANGE
BLUE	41	83	125	167	168	126	84	42	YELLOW



https://www.HaysElectrical.Com

THIS PRINT IS THE PROPERTY OF HAYS ELECTRICAL SERVICES. IT MUST NOT BE REPRODUCED IN ANY MANNER NOR SHALL IT BE SUBMITTED TO OUTSIDE PARTIES FOR EXAMINATION WITHOUT OUR CONSENT. IT SHALL BE USED ONLY AS A REFERENCE TO WORK DESIGNED OR FURNISHED BY US.

Project General Notes:
1. Rense layout as needed base on SPECS/A.E.C. requirement
2. Installed Junction Box at accessible location for future service access.
3.
4.



Revision Schedule	Revision Title		Date
	Number	Revision Title	Date
A	100% DESIGN DEVELOPMENT		9/30/26

100% DESIGN DEVELOPMENT
NOT FOR CONSTRUCTION

RAMBLER BATON ROUGE

BURBANK DR.
BATON ROUGE, LA


Project Number 26078
Date 09/30/26
Technician BKS
Superintendent WAW
Project Manager SS

LEVEL 6 WEST POWER PLAN


Sheet Number

E115

9/30/2026 2:13:14 PM

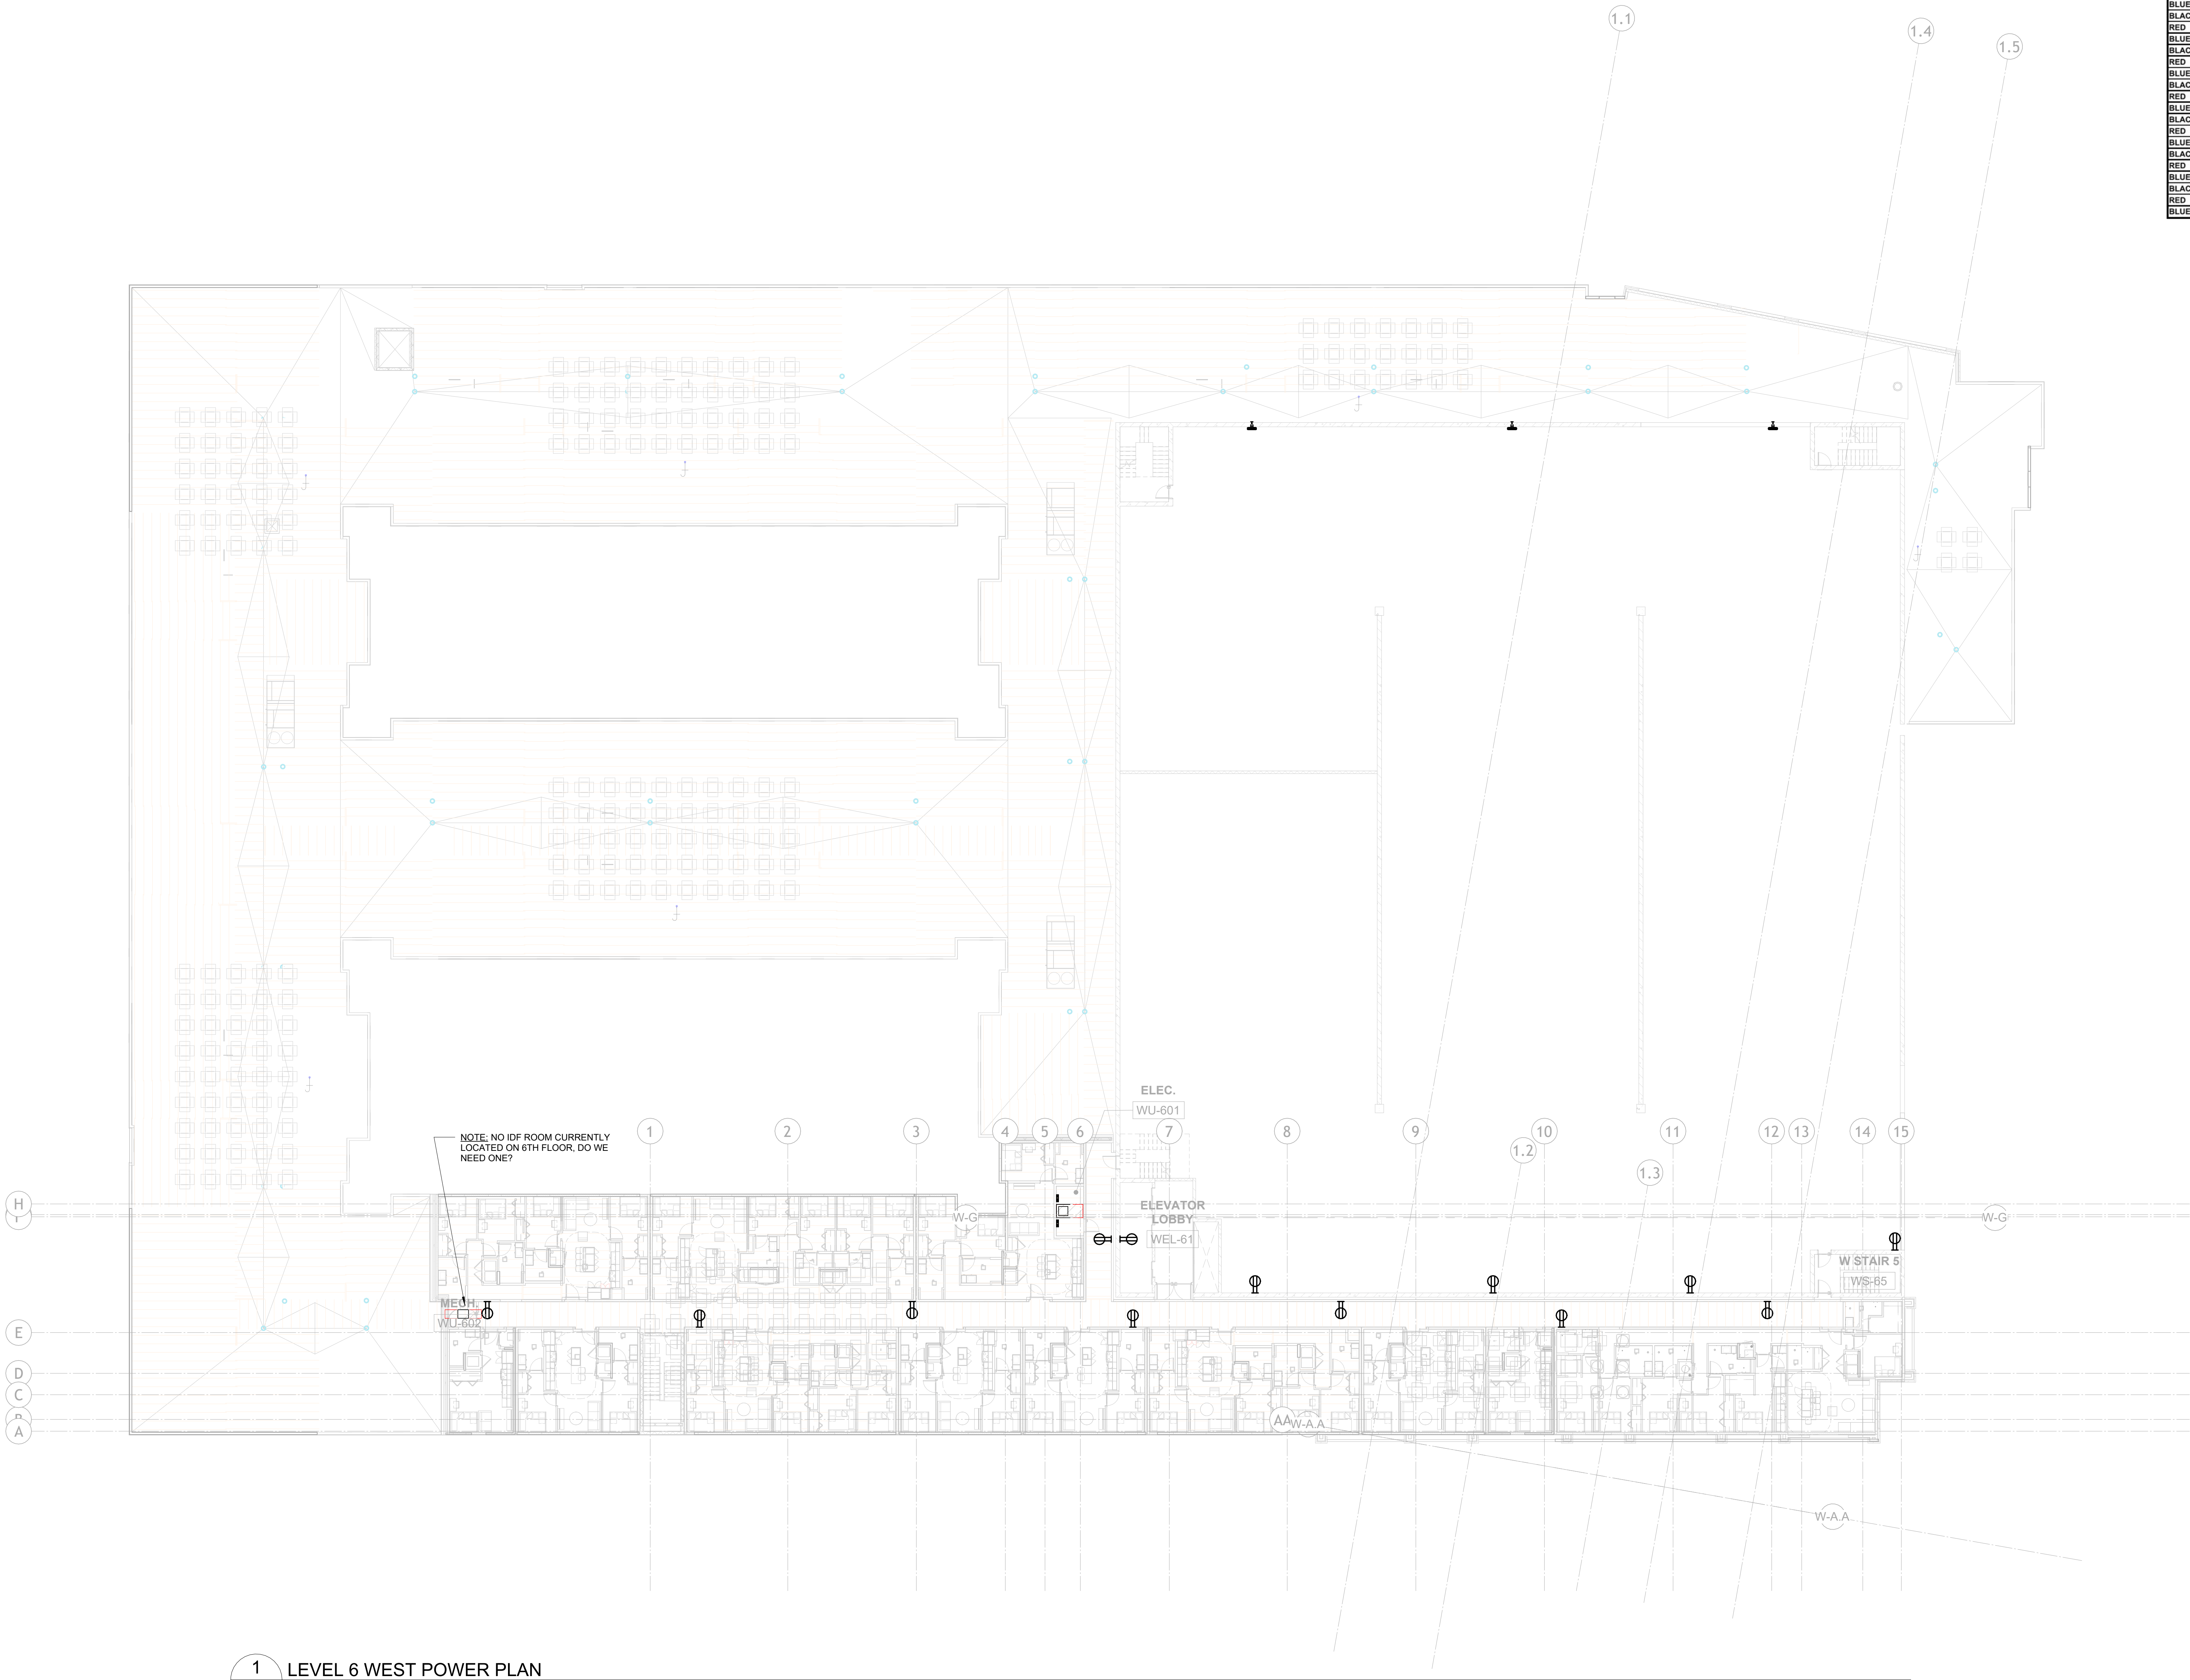

1 LEVEL 6 WEST POWER PLAN
E115 1/16" = 1'-0"

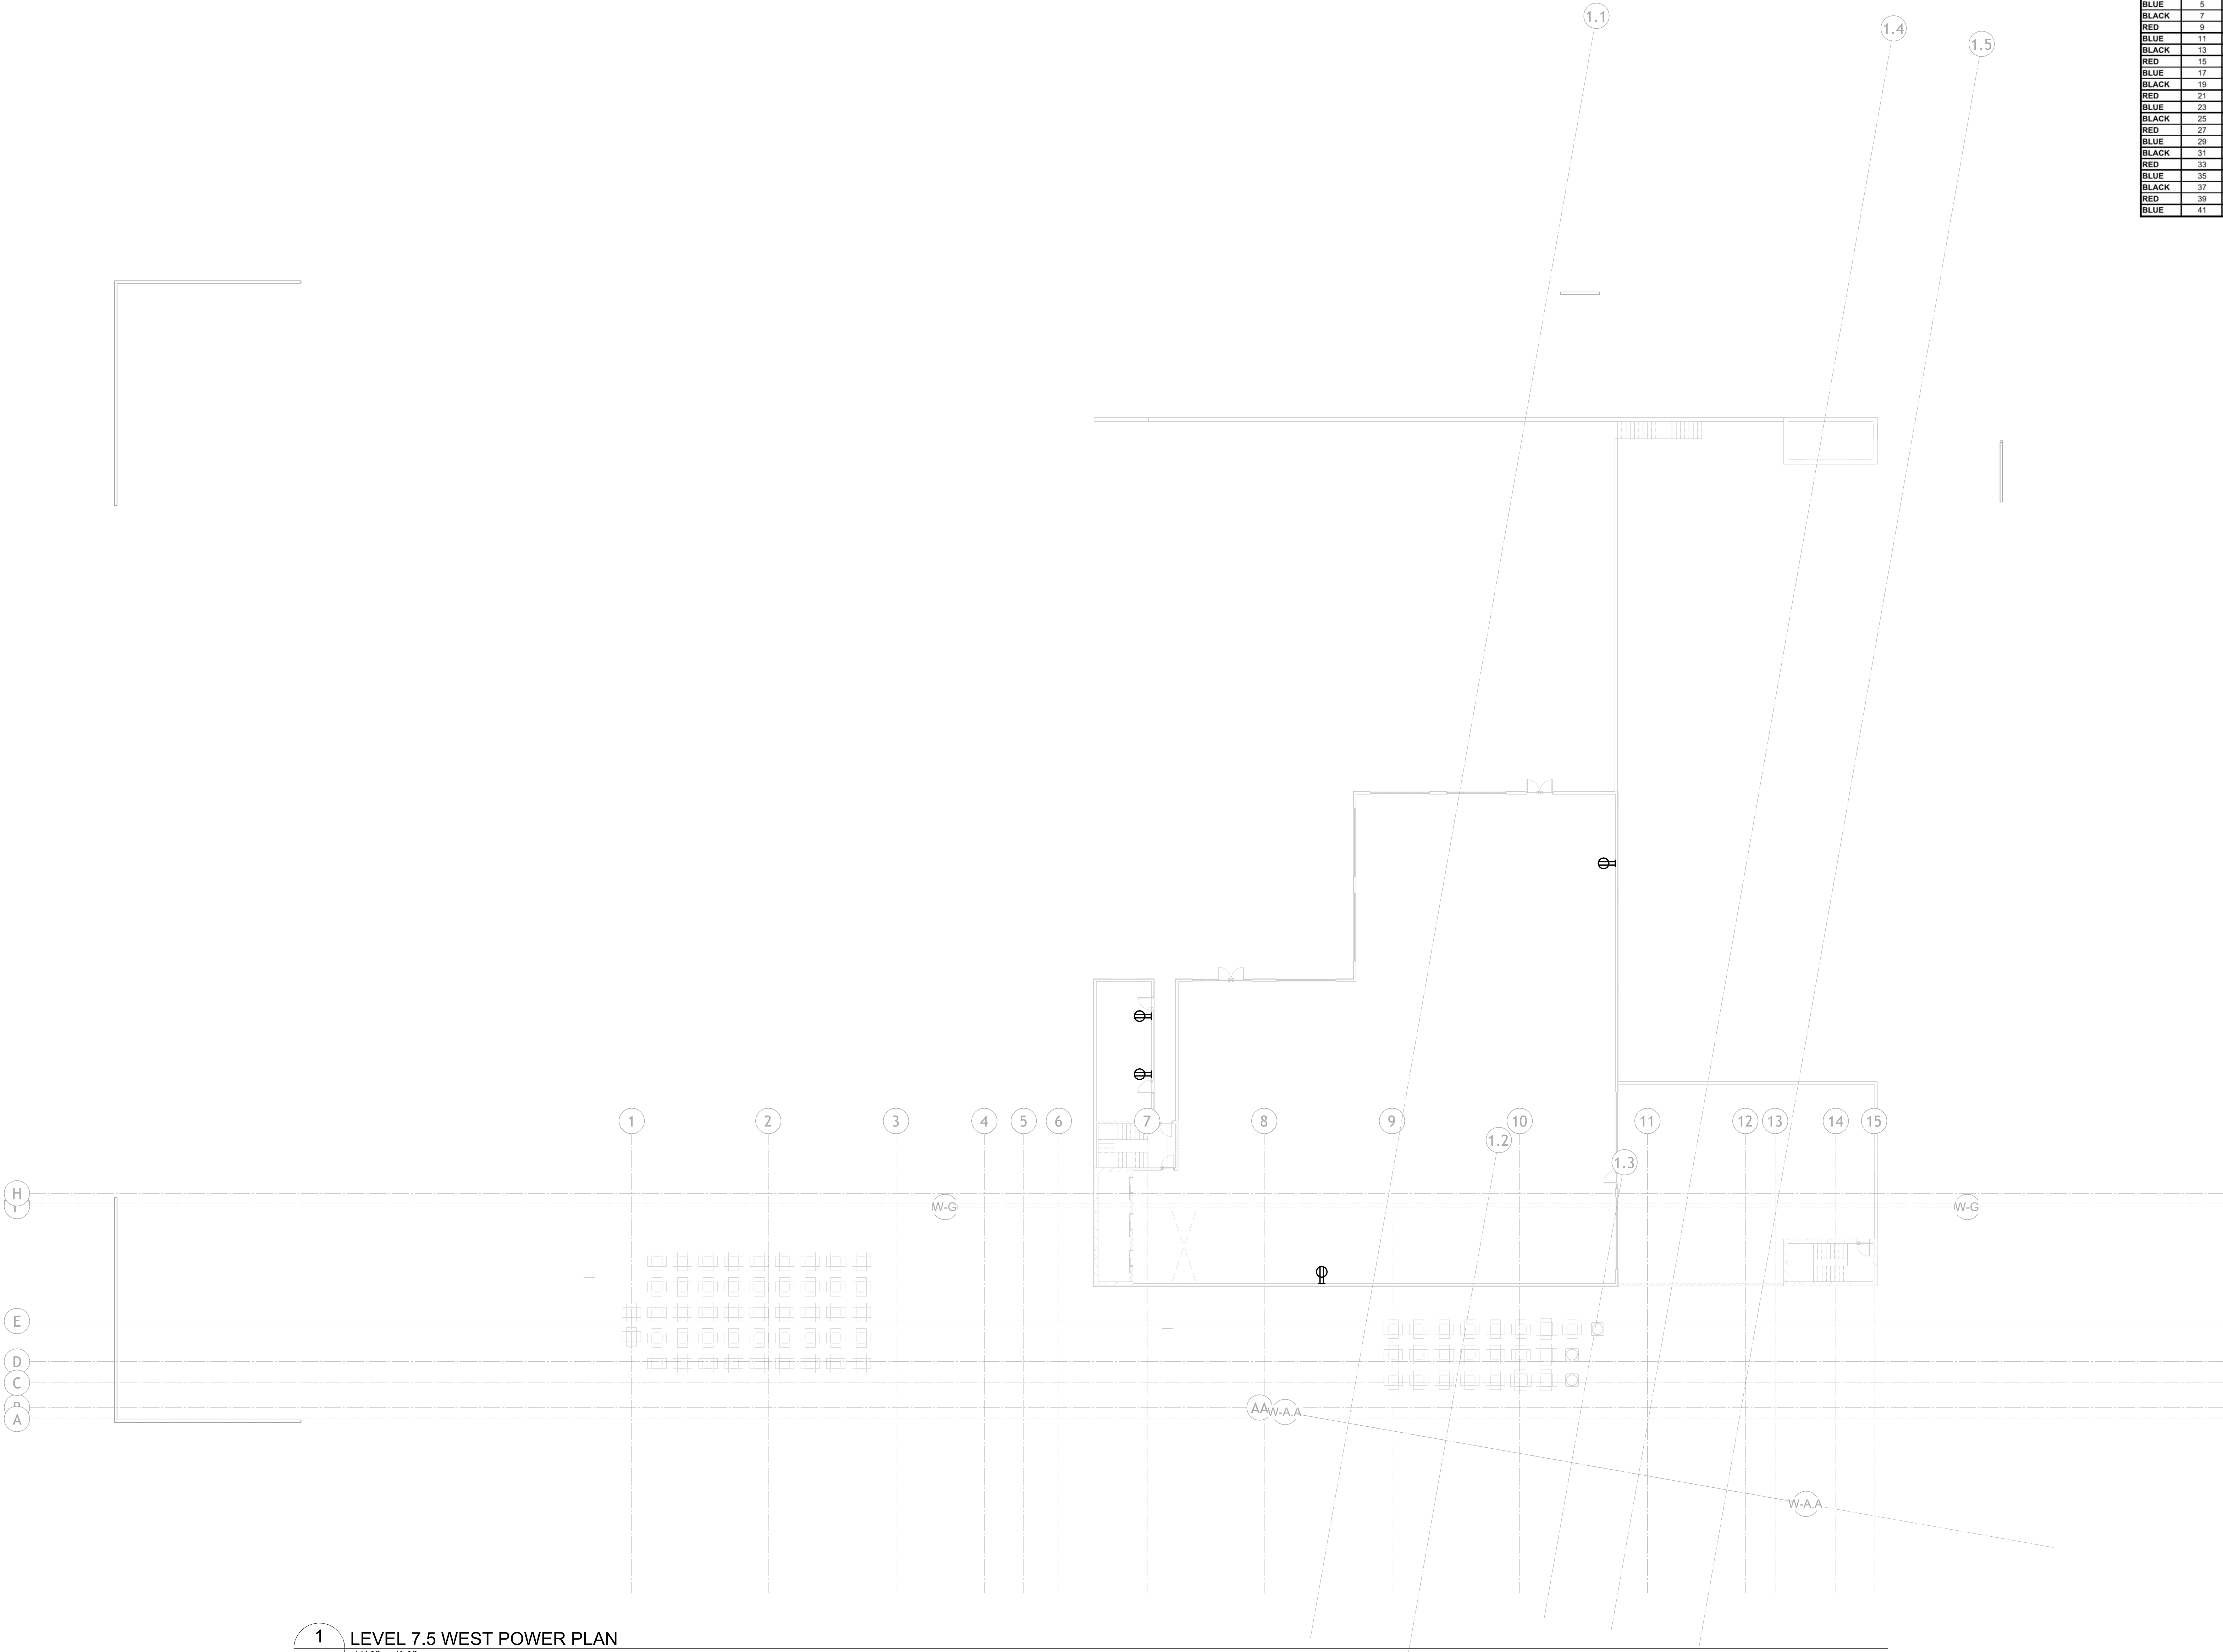

120/208V	SEC 1	SEC 2	SEC 3	SEC 4	SEC 3	SEC 2	SEC 1	277/480V
BLACK	1	43	85	127	128	86	44	2 BROWN
RED	3	45	87	129	130	88	46	4 ORANGE
BLUE	5	47	89	131	132	90	48	6 YELLOW
BLACK	7	49	91	133	134	92	50	8 BROWN
RED	9	51	93	135	136	94	52	10 ORANGE
BLUE	11	53	95	137	138	96	54	12 YELLOW
BLACK	13	55	97	139	140	98	56	14 BROWN
RED	15	57	99	141	142	100	58	16 ORANGE
BLUE	17	59	101	143	144	102	60	18 YELLOW
BLACK	19	61	103	145	146	104	62	20 BROWN
RED	21	63	105	147	148	106	64	22 ORANGE
BLUE	23	65	107	149	150	108	66	24 YELLOW
BLACK	25	67	109	151	152	110	68	26 BROWN
RED	27	69	111	153	154	112	70	28 ORANGE
BLUE	29	71	113	155	156	114	72	30 YELLOW
BLACK	31	73	115	157	158	116	74	32 BROWN
RED	33	75	117	159	160	118	76	34 ORANGE
BLUE	35	77	119	161	162	120	78	36 YELLOW
BLACK	37	79	121	163	164	122	80	38 BROWN
RED	39	81	123	165	166	124	82	40 ORANGE
BLUE	41	83	125	167	168	126	84	42 YELLOW

GENERAL NOTES

- REFER TO SHEET E000 FOR ADDITIONAL GENERAL NOTES.
- ALL WIRING SHALL BE INSTALLED IN CONDUIT UNLESS NOTED OTHERWISE.
- ALL BRANCH CIRCUIT WIRING TO BE THIN INDOORS, AND XHHW-2 OUTDOORS (INCLUDING ON ROOF), UNLESS OTHERWISE NOTED.
- ALL BRANCH CIRCUITS TO INCLUDE GREEN EQUIPMENT GROUND.
- NO SHARED NEUTRALS. EACH NEUTRAL MUST BE IDENTIFIED FOR ITS PHASE.
- ALL RECEPTACLES IN WET LOCATIONS, WITHIN 6' OF A SINK OR OUTDOORS TO BE GFCI.



https://www.HaysElectrical.Com

THIS PRINT IS THE PROPERTY OF HAYS ELECTRICAL SERVICES. IT MUST NOT BE REPRODUCED IN ANY MANNER NOR SHALL IT BE SUBMITTED TO OUTSIDE PARTIES FOR EXAMINATION WITHOUT OUR CONSENT. IT SHALL BE USED ONLY AS A REFERENCE TO WORK DESIGNED OR FURNISHED BY US.

Project General Notes:
1. Rense layout as needed base on SPECS/A.E.C. requirement
2. Installed junction box at accessible location for future service access.
3.
4.



Revision Schedule		Date
Number	Revision Title	
A	100% DESIGN DEVELOPMENT	9/30/26

100% DESIGN DEVELOPMENT
NOT FOR CONSTRUCTION

RAMBLER BATON ROUGE

BURBANK DR.
BATON ROUGE, LA

Project Number 26078
Date 09/30/26
Technician BKS
Superintendent WAW
Project Manager SS

LEVEL 7.5 WEST POWER PLAN

Sheet Number
E116

120/208V	SEC 1	SEC 2	SEC 3	SEC 4	SEC 3	SEC 2	SEC 1	277/480V
BLACK	1	43	85	127	128	86	44	2 BROWN
RED	3	45	87	129	130	88	46	4 ORANGE
BLUE	5	47	89	131	132	90	48	6 YELLOW
BLACK	7	49	91	133	134	92	50	8 BROWN
RED	9	51	93	135	136	94	52	10 ORANGE
BLUE	11	53	95	137	138	96	54	12 YELLOW
BLACK	13	55	97	139	140	98	56	14 BROWN
RED	15	57	99	141	142	100	58	16 ORANGE
BLUE	17	59	101	143	144	102	60	18 YELLOW
BLACK	19	61	103	145	146	104	62	20 BROWN
RED	21	63	105	147	148	106	64	22 ORANGE
BLUE	23	65	107	149	150	108	66	24 YELLOW
BLACK	25	67	109	151	152	110	68	26 BROWN
RED	27	69	111	153	154	112	70	28 ORANGE
BLUE	29	71	113	155	156	114	72	30 YELLOW
BLACK	31	73	115	157	158	116	74	32 BROWN
RED	33	75	117	159	160	118	76	34 ORANGE
BLUE	35	77	119	161	162	120	78	36 YELLOW
BLACK	37	79	121	163	164	122	80	38 BROWN
RED	39	81	123	165	166	124	82	40 ORANGE
BLUE	41	83	125	167	168	126	84	42 YELLOW



https://www.HaysElectrical.Com

THIS PRINT IS THE PROPERTY OF HAYS ELECTRICAL SERVICES. IT MUST NOT BE REPRODUCED IN ANY MANNER NOR SHALL IT BE SUBMITTED TO OUTSIDE PARTIES FOR EXAMINATION WITHOUT OUR CONSENT. IT SHALL BE USED ONLY AS A REFERENCE TO WORK DESIGNED OR FURNISHED BY US.

Project General Notes:
1. Reroute layout as needed base on SPECS/A.E.C. requirement
2. Installed junction box at accessible location for future service access.
3.
4.



Revision Schedule	Revision Title		Date	
	Number	Revision Title	Date	
A	100% DESIGN DEVELOPMENT		9/30/26	

100% DESIGN DEVELOPMENT
NOT FOR CONSTRUCTION

RAMBLER BATON ROUGE


BURBANK DR.
BATON ROUGE, LA

Project Number 26078
Date 09/30/26
Technician BKS
Superintendent WAW
Project Manager SS


LEVEL 8 WEST POWER
PLAN

Sheet Number

E117

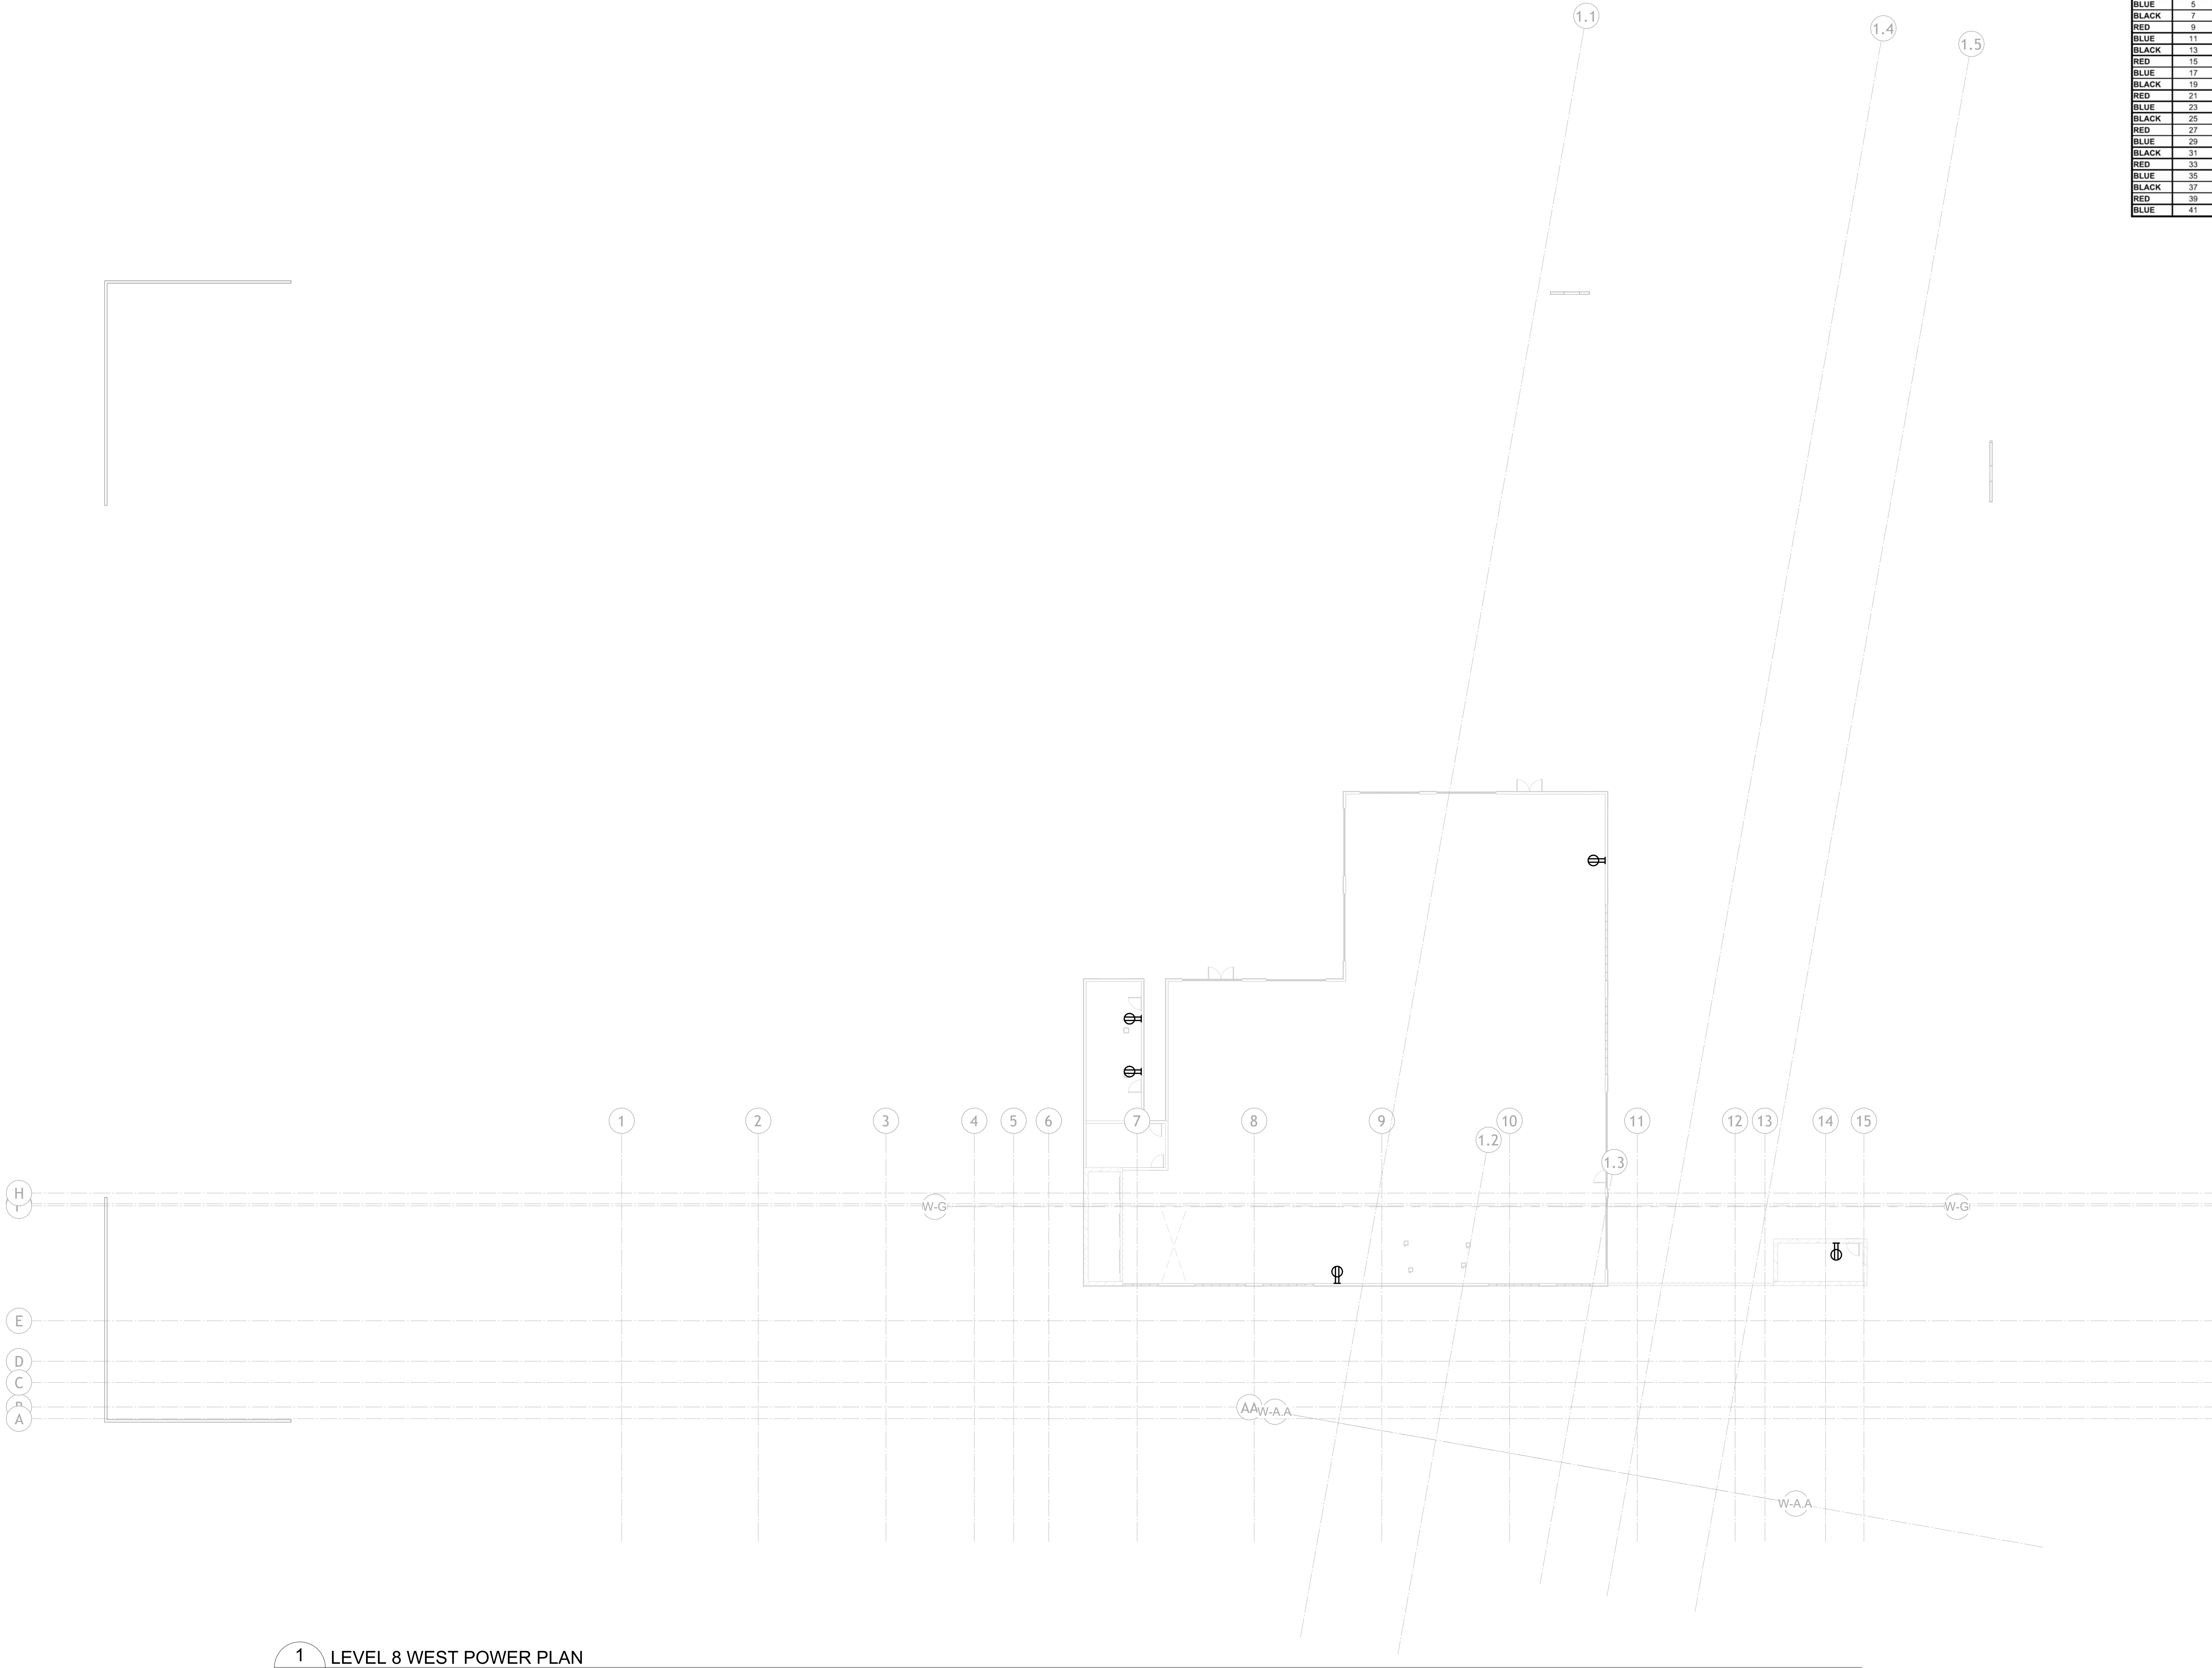

1 LEVEL 8 WEST POWER PLAN
E117 1/16" = 1'-0"

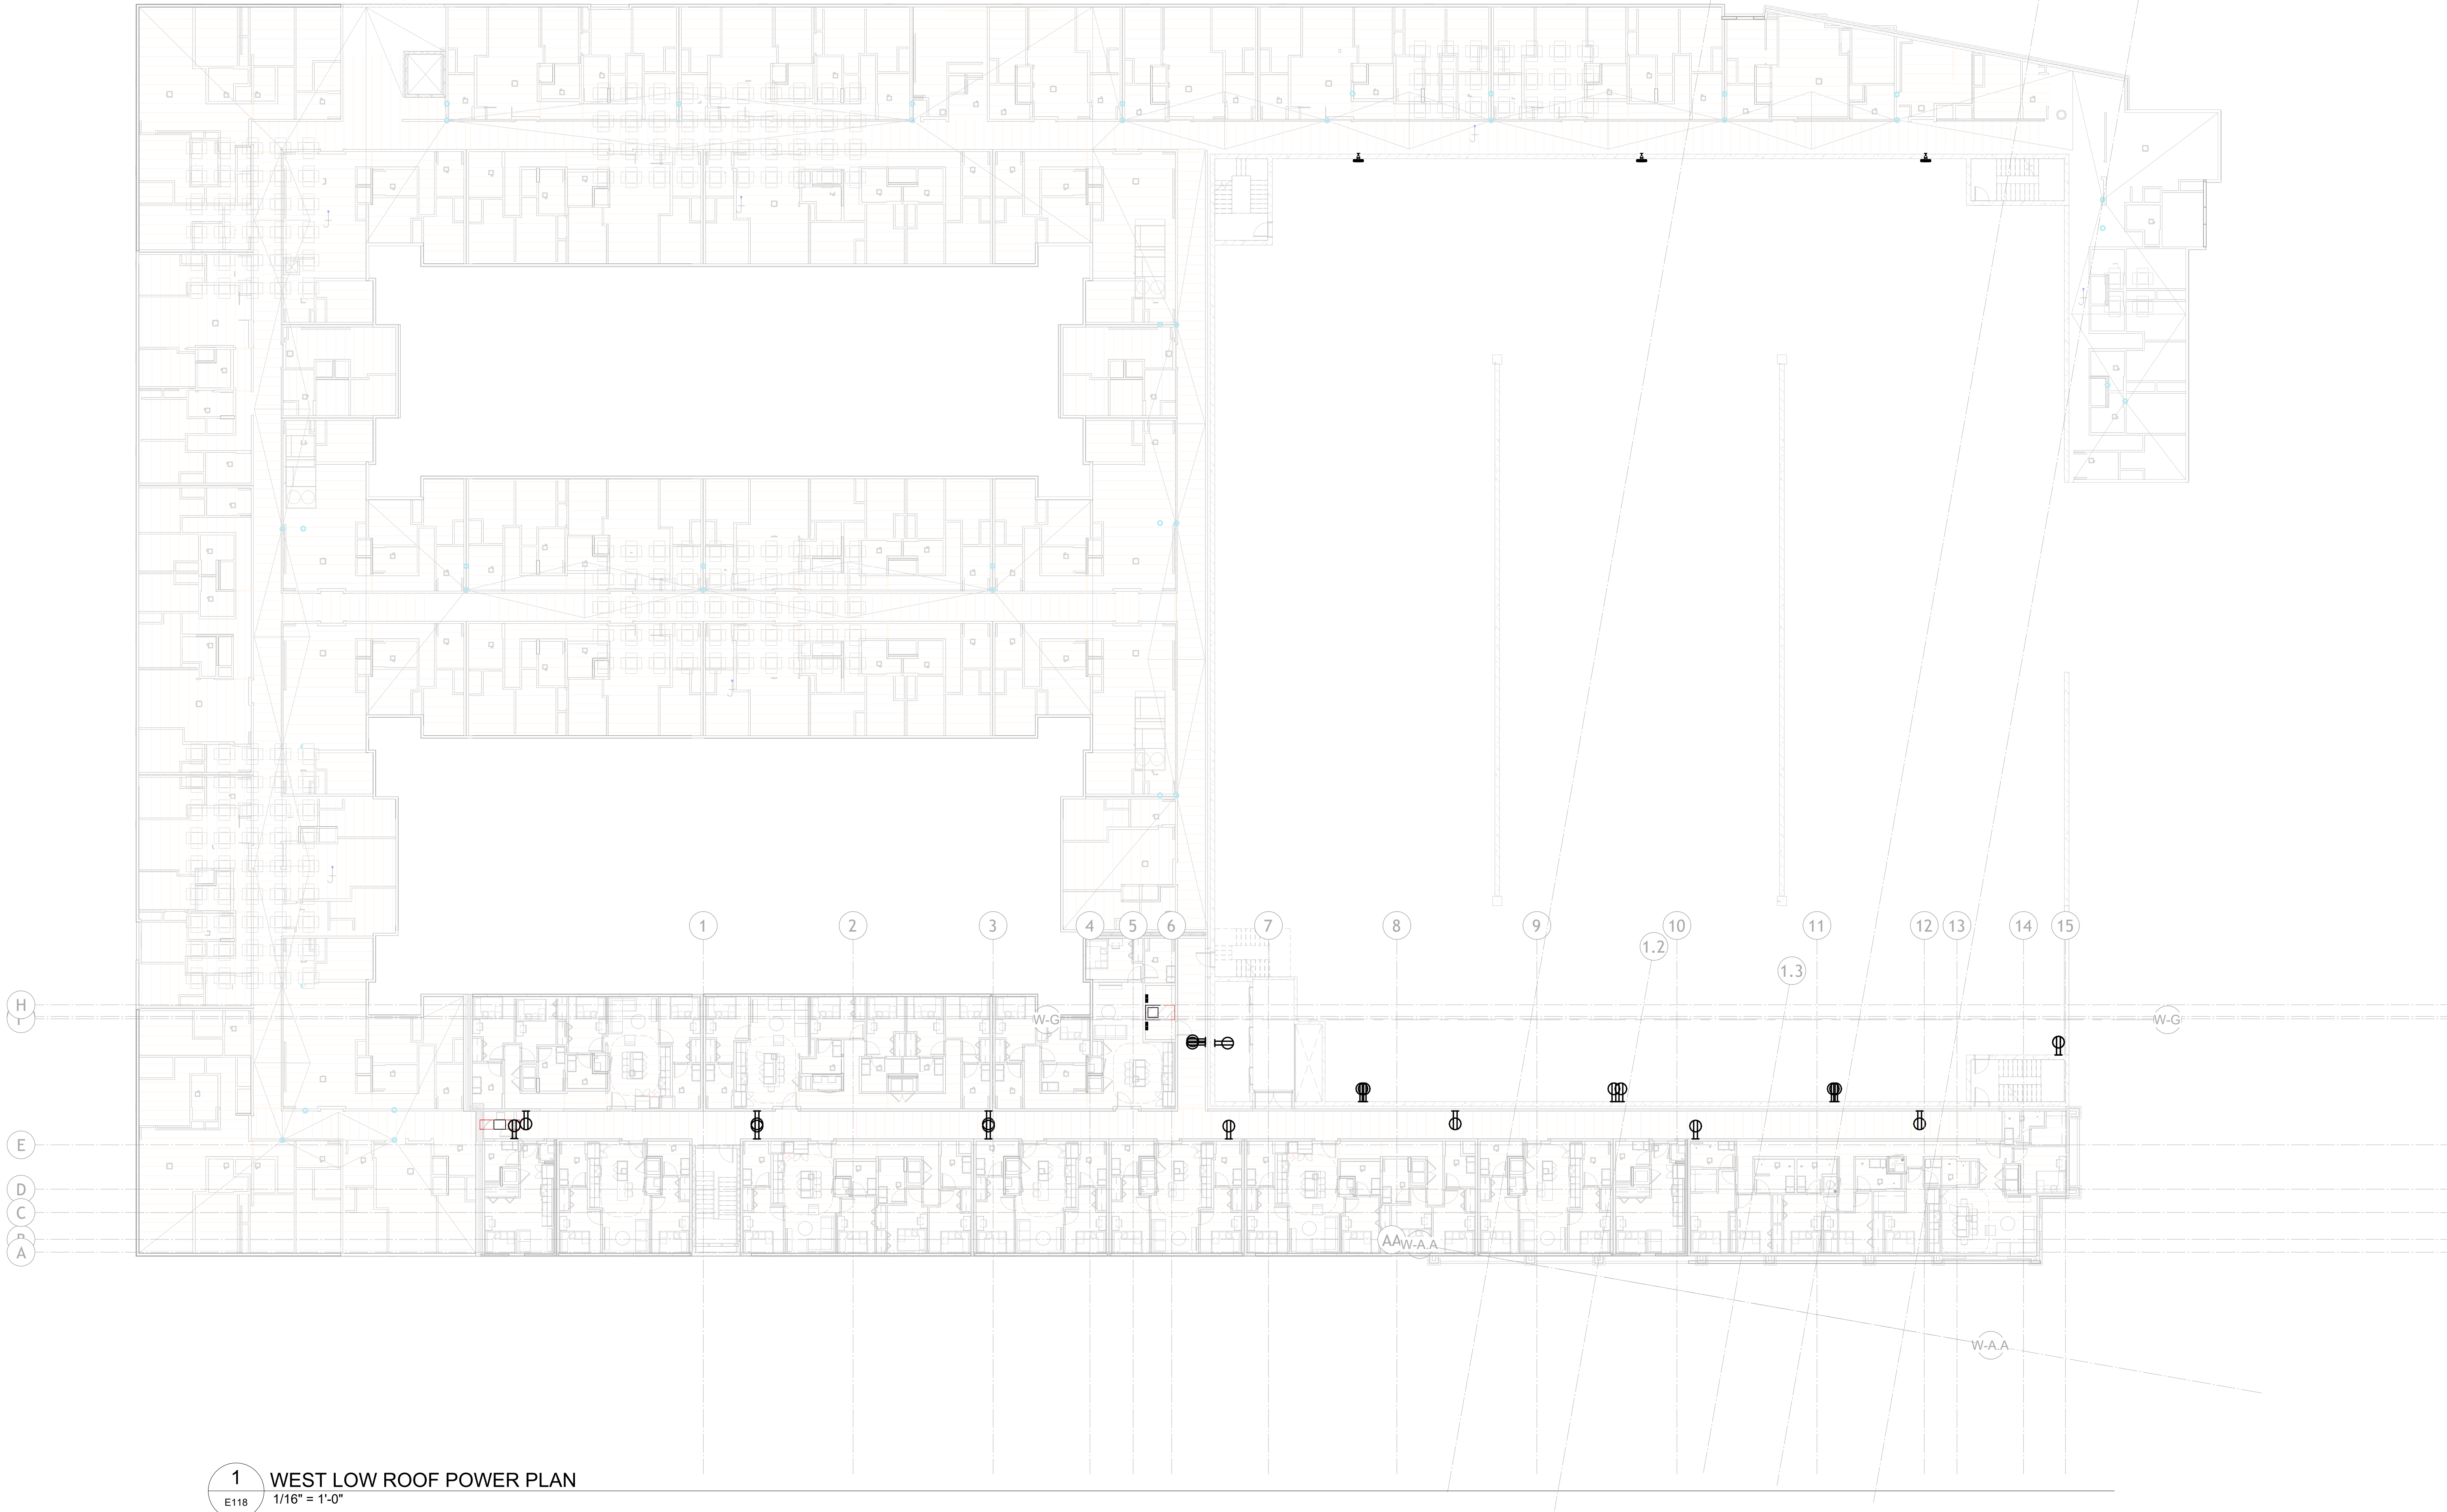

1 WEST LOW ROOF POWER PLAN
E118 1/16" = 1'-0"

120/208V	SEC 1	SEC 2	SEC 3	SEC 4	SEC 4	SEC 3	SEC 2	SEC 1	277/480V
BLACK	1	43	85	127	128	86	44	2	BROWN
RED	3	45	87	129	130	88	46	4	ORANGE
BLUE	5	47	89	131	132	90	48	6	YELLOW
BLACK	7	49	91	133	134	92	50	8	BROWN
RED	9	51	93	135	136	94	52	10	ORANGE
BLUE	11	53	95	137	138	96	54	12	YELLOW
BLACK	13	55	97	139	140	98	56	14	BROWN
RED	15	57	99	141	142	100	58	16	ORANGE
BLUE	17	59	101	143	144	102	60	18	YELLOW
BLACK	19	61	103	145	146	104	62	20	BROWN
RED	21	63	105	147	148	106	64	22	ORANGE
BLUE	23	65	107	149	150	108	66	24	YELLOW
BLACK	25	67	109	151	152	110	68	26	BROWN
RED	27	69	111	153	154	112	70	28	ORANGE
BLUE	29	71	113	155	156	114	72	30	YELLOW
BLACK	31	73	115	157	158	116	74	32	BROWN
RED	33	75	117	159	160	118	76	34	ORANGE
BLUE	35	77	119	161	162	120	78	36	YELLOW
BLACK	37	79	121	163	164	122	80	38	BROWN
RED	39	81	123	165	166	124	82	40	ORANGE
BLUE	41	83	125	167	168	126	84	42	YELLOW

GENERAL NOTES

- REFER TO SHEET E000 FOR ADDITIONAL GENERAL NOTES.
- ALL WIRING SHALL BE INSTALLED IN CONDUIT UNLESS NOTED OTHERWISE.
- ALL BRANCH CIRCUIT WIRING TO BE THIN INDOORS, AND XHHW-2 OUTDOORS (INCLUDING ON ROOF), UNLESS OTHERWISE NOTED.
- ALL BRANCH CIRCUITS TO INCLUDE GREEN EQUIPMENT GROUND.
- NO SHARED NEUTRALS. EACH NEUTRAL MUST BE IDENTIFIED FOR ITS PHASE.
- ALL RECEPTACLES IN WET LOCATIONS, WITHIN 6' OF A SINK OR OUTDOORS TO BE GFCI.

Project General Notes:
1. Rense layout as needed base on SPECS/A.E.C. requirement
2. Installed Junction Box at accessible location for future service access.
3.
4.

Revision Schedule	Revision Title		Date
	Number	Revision Title	Date
A	100% DESIGN DEVELOPMENT		9/30/26

100% DESIGN DEVELOPMENT
NOT FOR CONSTRUCTION

RAMBLER BATON ROUGE

BURBANK DR.
BATON ROUGE, LA

Project Number 26078
Date 09/30/26
Technician BKS
Superintendent WAW
Project Manager SS

WEST LOW ROOF POWER
PLAN


Sheet Number
E118



https://www.HaysElectrical.Com

THIS PRINT IS THE PROPERTY OF
HAYS ELECTRICAL SERVICES. IT
MUST NOT BE REPRODUCED IN ANY
MANNER NOR SHALL IT BE
SUBMITTED TO OUTSIDE PARTIES
FOR EXAMINATION WITHOUT OUR
CONSENT. IT SHALL BE USED ONLY
AS A REFERENCE TO WORK
DESIGNED OR FURNISHED BY US.



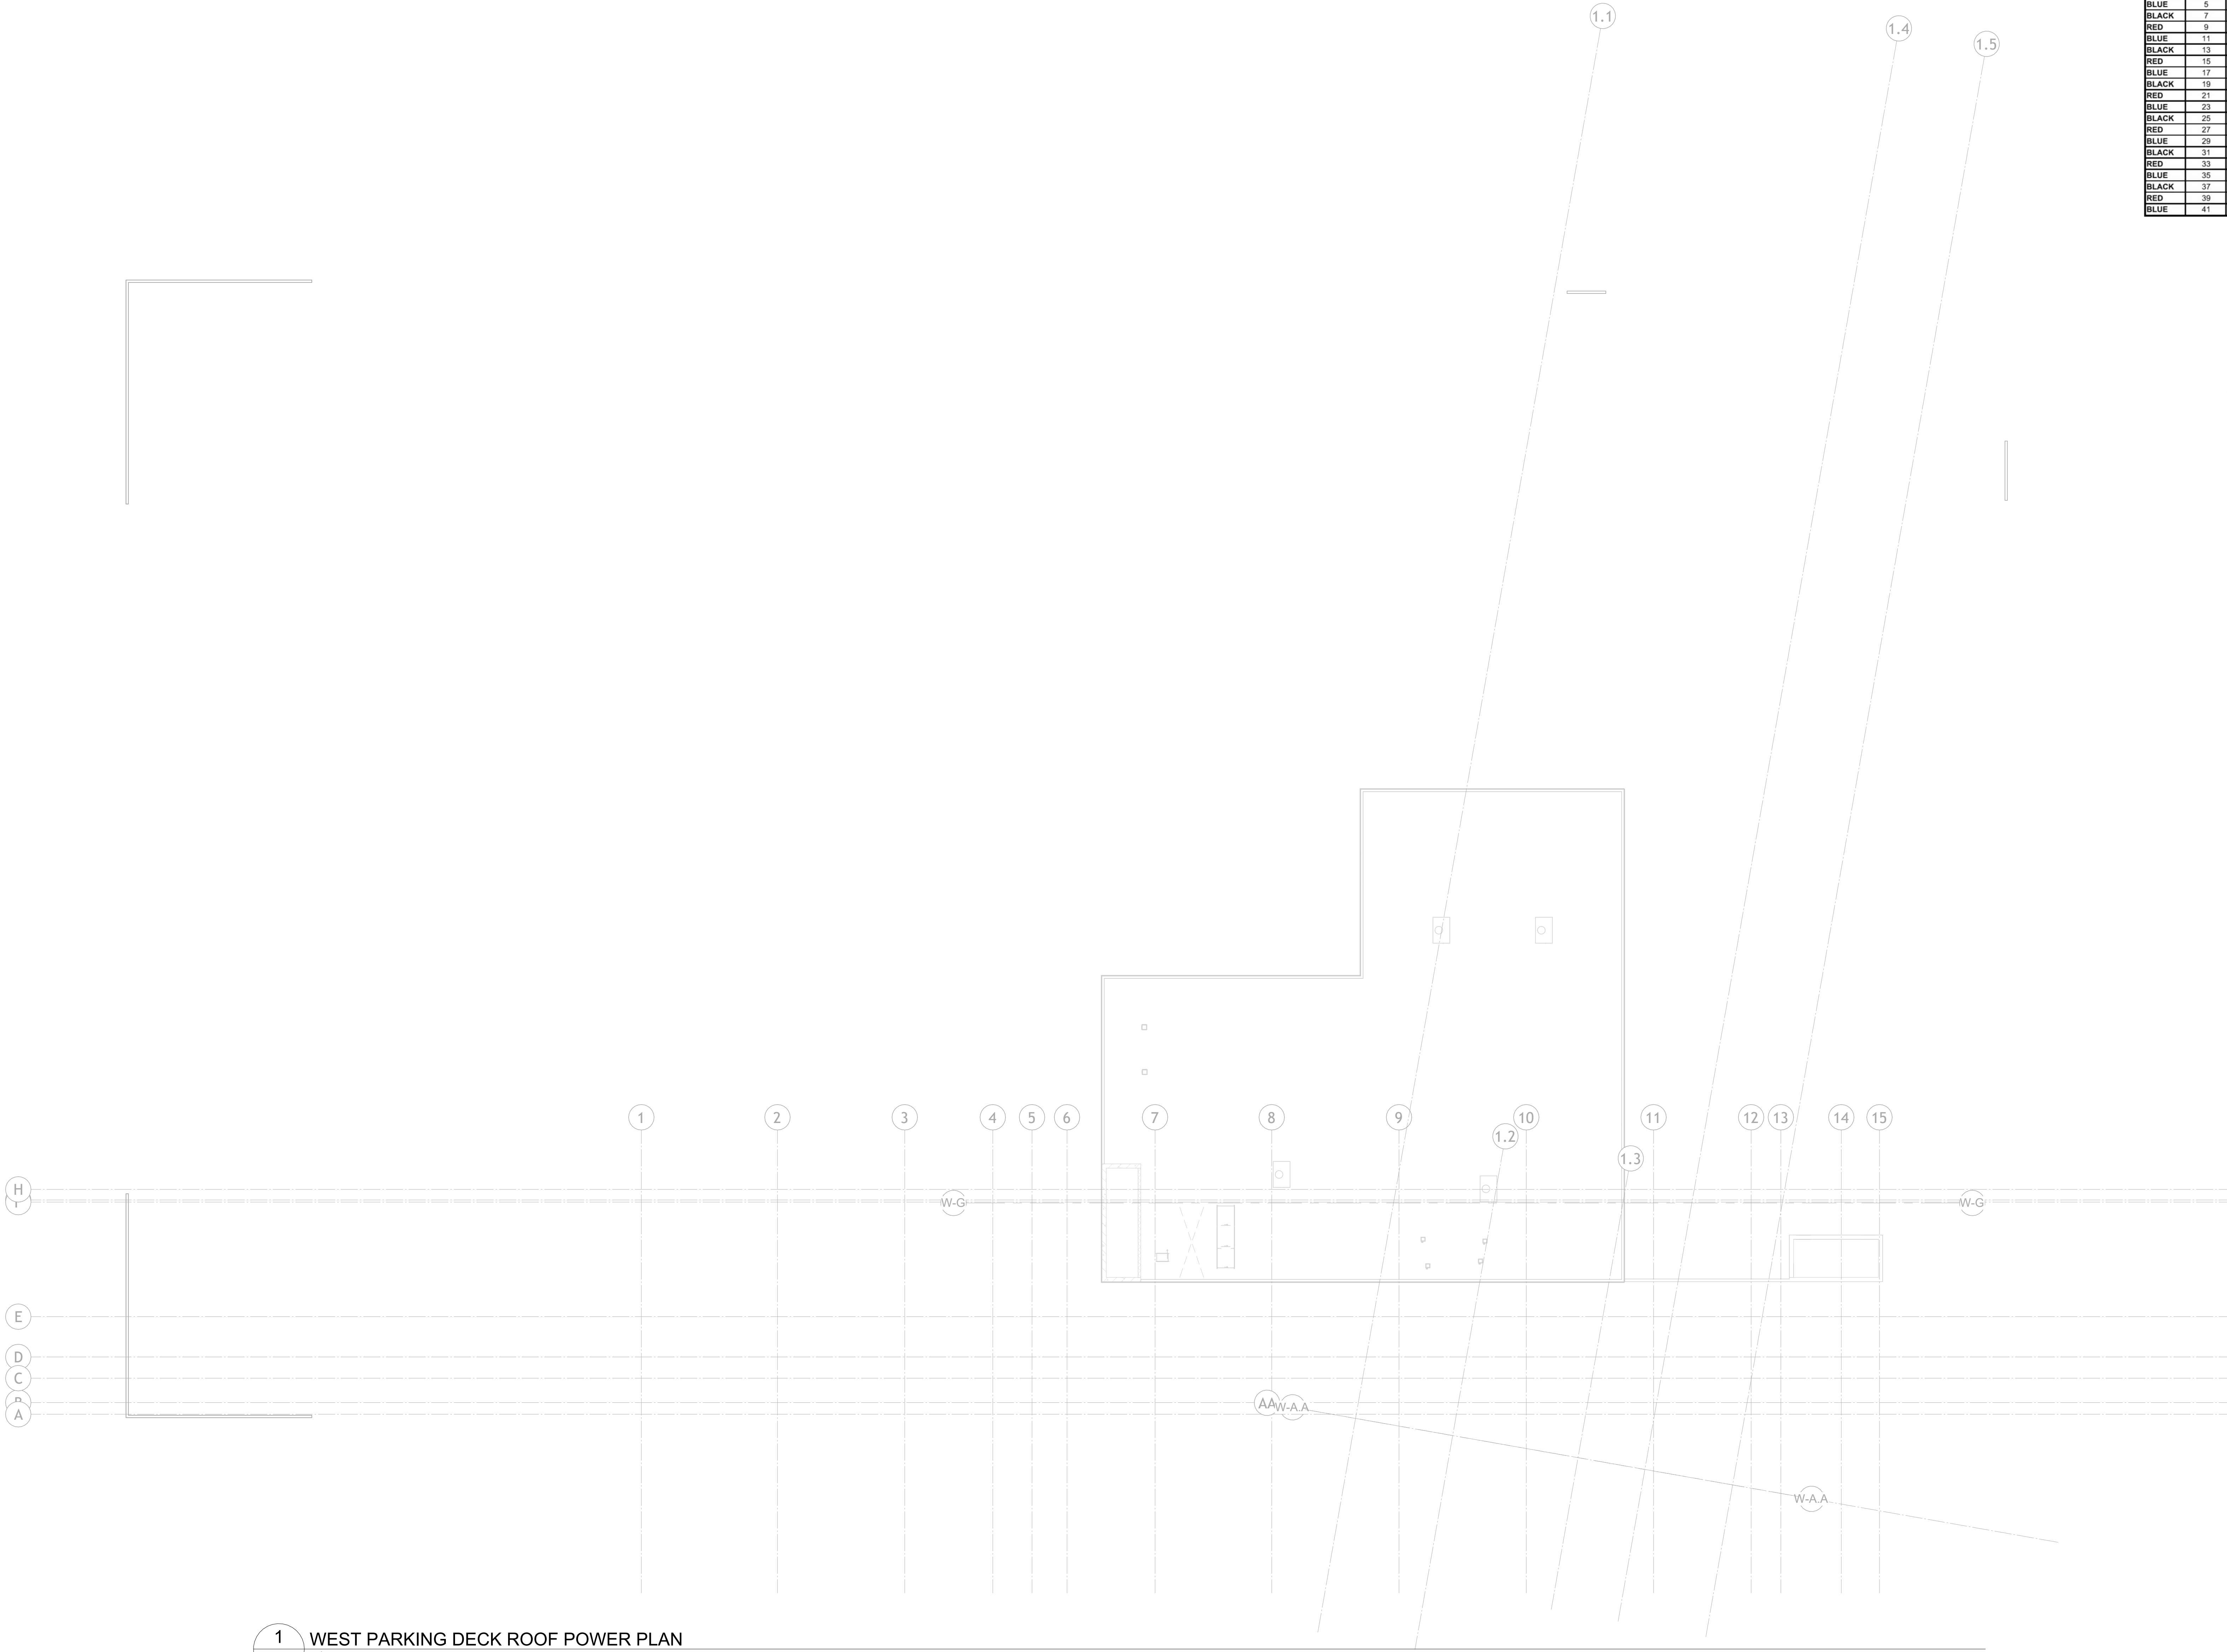

1 WEST PARKING DECK ROOF POWER PLAN
E120 1/16" = 1'-0"

120/208V	SEC 1	SEC 2	SEC 3	SEC 4	SEC 3	SEC 2	SEC 1	277/480V
BLACK	1	43	85	127	128	86	44	2 BROWN
RED	3	45	87	129	130	88	46	4 ORANGE
BLUE	5	47	89	131	132	90	48	6 YELLOW
BLACK	7	49	91	133	134	92	50	8 BROWN
RED	9	51	93	135	136	94	52	10 ORANGE
BLUE	11	53	95	137	138	96	54	12 YELLOW
BLACK	13	55	97	139	140	98	56	14 BROWN
RED	15	57	99	141	142	100	58	16 ORANGE
BLUE	17	59	101	143	144	102	60	18 YELLOW
BLACK	19	61	103	145	146	104	62	20 BROWN
RED	21	63	105	147	148	106	64	22 ORANGE
BLUE	23	65	107	149	150	108	66	24 YELLOW
BLACK	25	67	109	151	152	110	68	26 BROWN
RED	27	69	111	153	154	112	70	28 ORANGE
BLUE	29	71	113	155	156	114	72	30 YELLOW
BLACK	31	73	115	157	158	116	74	32 BROWN
RED	33	75	117	159	160	118	76	34 ORANGE
BLUE	35	77	119	161	162	120	78	36 YELLOW
BLACK	37	79	121	163	164	122	80	38 BROWN
RED	39	81	123	165	166	124	82	40 ORANGE
BLUE	41	83	125	167	168	126	84	42 YELLOW

GENERAL NOTES

- REFER TO SHEET E000 FOR ADDITIONAL GENERAL NOTES.
- ALL WIRING SHALL BE INSTALLED IN CONDUIT UNLESS NOTED OTHERWISE.
- ALL BRANCH CIRCUIT WIRING TO BE THIN INDOORS, AND XHHW-2 OUTDOORS (INCLUDING ON ROOF), UNLESS OTHERWISE NOTED.
- ALL BRANCH CIRCUITS TO INCLUDE GREEN EQUIPMENT GROUND.
- NO SHARED NEUTRALS, EACH NEUTRAL MUST BE IDENTIFIED FOR ITS PHASE.
- ALL RECEPTACLES IN WET LOCATIONS, WITHIN 6' OF A SINK OR OUTDOORS TO BE GFCI.

Project General Notes:
1. Rense layout as needed base on SPECS/A.E.C. requirement
2. Installed junction box at accessible location for future service access.
3.
4.

Revision Schedule			Date
Number	Revision Title		
A	100% DESIGN DEVELOPMENT		9/30/26

100% DESIGN DEVELOPMENT
NOT FOR CONSTRUCTION

RAMBLER BATON ROUGE

BURBANK DR.
BATON ROUGE, LA

Project Number 26078
Date 09/30/26
Technician ALN
Superintendent WAW
Project Manager SS

WEST PARKING DECK
ROOF POWER PLAN

Sheet Number

E120

GENERAL NOTES

1. REFER TO SHEET E000 FOR ADDITIONAL GENERAL NOTES.
2. ALL WIRING SHALL BE INSTALLED IN CONDUIT UNLESS NOTED OTHERWISE.
3. ALL BRANCH CIRCUIT WIRING TO BE THIN INDOORS, AND XHHW-2 OUTDOORS (INCLUDING ON ROOF), UNLESS OTHERWISE NOTED.
4. ALL BRANCH CIRCUITS TO INCLUDE GREEN EQUIPMENT GROUND.
5. NO SHARED NEUTRALS. EACH NEUTRAL MUST BE IDENTIFIED FOR ITS PHASE.
6. ALL RECEPTACLES IN WET LOCATIONS, WITHIN 6' OF A SINK OR OUTDOORS TO BE GFCI.

120/208V	SEC 1	SEC 2	SEC 3	SEC 4	SEC 3	SEC 2	SEC 1	277/480V
BLACK	1	43	85	127	128	86	44	2 BROWN
RED	3	45	87	129	130	88	46	4 ORANGE
BLUE	5	47	89	131	132	90	48	6 YELLOW
BLACK	7	49	91	133	134	92	50	8 BROWN
RED	9	51	93	135	136	94	52	10 ORANGE
BLUE	11	53	95	137	138	96	54	12 YELLOW
BLACK	13	55	97	139	140	98	56	14 BROWN
RED	15	57	99	141	142	100	58	16 ORANGE
BLUE	17	59	101	143	144	102	60	18 YELLOW
BLACK	19	61	103	145	146	104	62	20 BROWN
RED	21	63	105	147	148	106	64	22 ORANGE
BLUE	23	65	107	149	150	108	66	24 YELLOW
BLACK	25	67	109	151	152	110	68	26 BROWN
RED	27	69	111	153	154	112	70	28 ORANGE
BLUE	29	71	113	155	156	114	72	30 YELLOW
BLACK	31	73	115	157	158	116	74	32 BROWN
RED	33	75	117	159	160	118	76	34 ORANGE
BLUE	35	77	119	161	162	120	78	36 YELLOW
BLACK	37	79	121	163	164	122	80	38 BROWN
RED	39	81	123	165	166	124	82	40 ORANGE
BLUE	41	83	125	167	168	126	84	42 YELLOW



https://www.HaysElectrical.Com

THIS PRINT IS THE PROPERTY OF HAYS ELECTRICAL SERVICES. IT MUST NOT BE REPRODUCED IN ANY MANNER NOR SHALL IT BE SUBMITTED TO OUTSIDE PARTIES FOR EXAMINATION WITHOUT OUR CONSENT. IT SHALL BE USED ONLY AS A REFERENCE TO WORK DESIGNED OR FURNISHED BY US.

Project General Notes:
1. Rense layout as needed base on SPECS/A.E.C. requirement
2. Installed junction box at accessible location for future service access.
3.
4.



Revision Schedule		Date
Number	Revision Title	
A	100% DESIGN DEVELOPMENT	9/30/26

100% DESIGN DEVELOPMENT
NOT FOR CONSTRUCTION

RAMBLER BATON ROUGE

BURBANK DR.
BATON ROUGE, LA


Project Number 26078
Date 09/30/26
Technician ALN
Superintendent WAW
Project Manager SS

LEVEL 1 EAST POWER PLAN

Sheet Number

E121

9/30/2026 2:14:00 PM

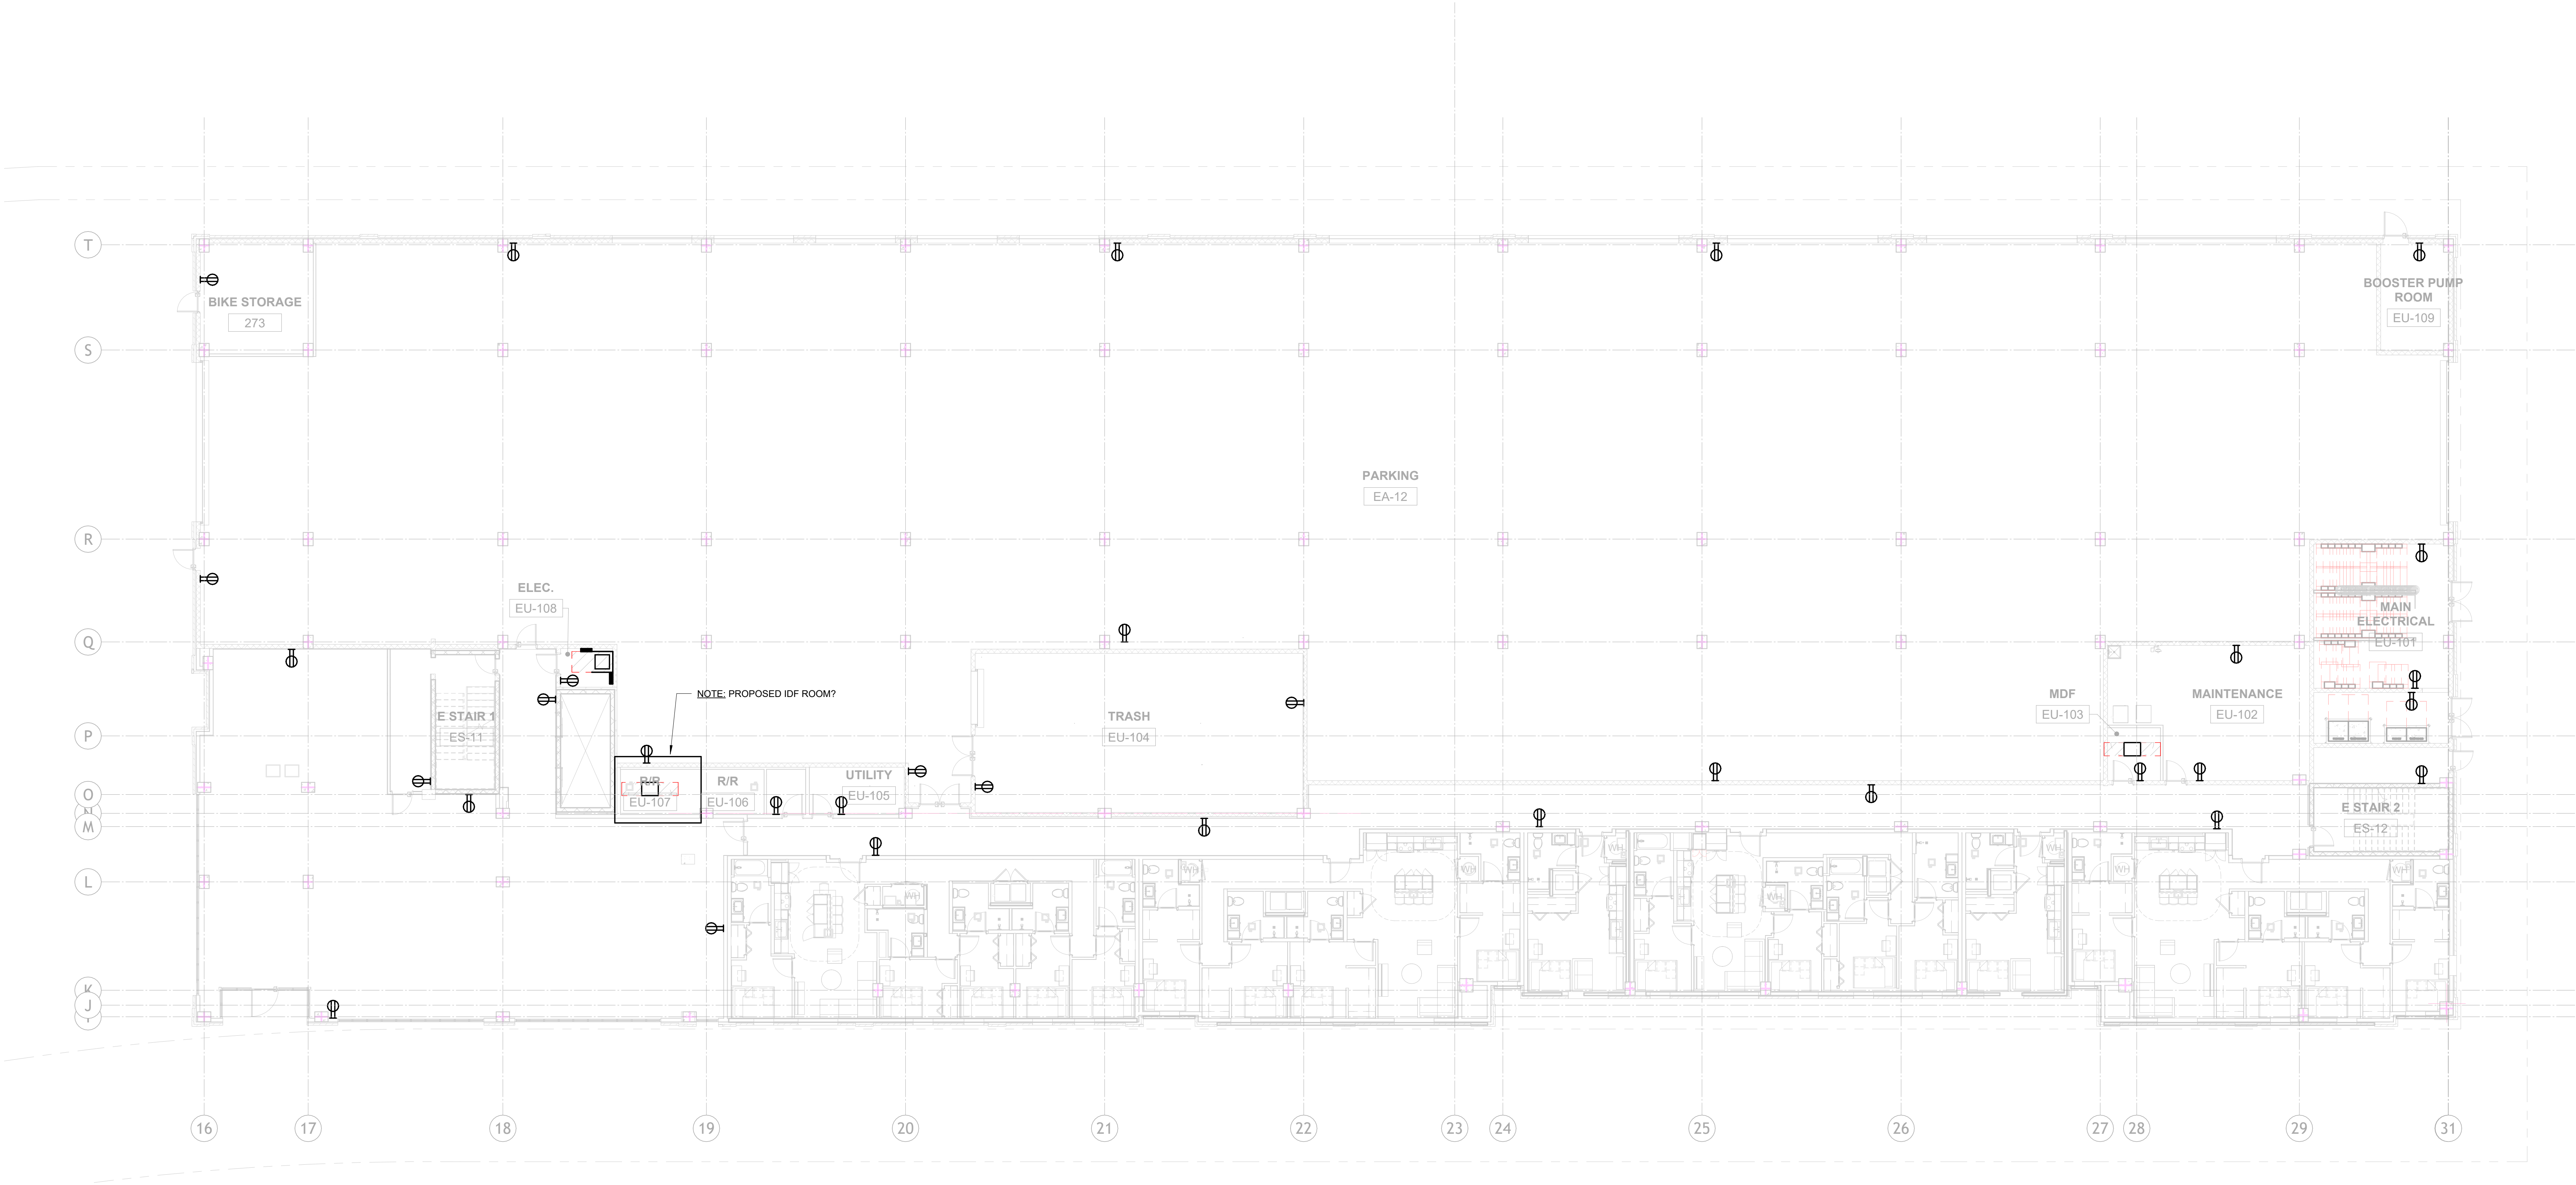

1 LEVEL 1 EAST POWER PLAN
E121 3/32" = 1'-0"

GENERAL NOTES

- REFER TO SHEET E000 FOR ADDITIONAL GENERAL NOTES.
- ALL WIRING SHALL BE INSTALLED IN CONDUIT UNLESS NOTED OTHERWISE.
- ALL BRANCH CIRCUIT WIRING TO BE THIN INDOORS, AND XHHW-2 OUTDOORS (INCLUDING ON ROOF), UNLESS OTHERWISE NOTED.
- ALL BRANCH CIRCUITS TO INCLUDE GREEN EQUIPMENT GROUND.
- NO SHARED NEUTRALS, EACH NEUTRAL MUST BE IDENTIFIED FOR ITS PHASE.
- ALL RECEPTACLES IN WET LOCATIONS, WITHIN 6' OF A SINK OR OUTDOORS TO BE GFCI.

120/208V	SEC 1	SEC 2	SEC 3	SEC 4	SEC 4	SEC 3	SEC 2	SEC 1	277/480V
BLACK	1	43	85	127	128	86	44	2	BROWN
RED	3	45	87	129	130	88	46	4	ORANGE
BLUE	5	47	89	131	132	90	48	6	YELLOW
BLACK	7	49	91	133	134	92	50	8	BROWN
RED	9	51	93	135	136	94	52	10	ORANGE
BLUE	11	53	95	137	138	96	54	12	YELLOW
BLACK	13	55	97	139	140	98	56	14	BROWN
RED	15	57	99	141	142	100	58	16	ORANGE
BLUE	17	59	101	143	144	102	60	18	YELLOW
BLACK	19	61	103	145	146	104	62	20	BROWN
RED	21	63	105	147	148	106	64	22	ORANGE
BLUE	23	65	107	149	150	108	66	24	YELLOW
BLACK	25	67	109	151	152	110	68	26	BROWN
RED	27	69	111	153	154	112	70	28	ORANGE
BLUE	29	71	113	155	156	114	72	30	YELLOW
BLACK	31	73	115	157	158	116	74	32	BROWN
RED	33	75	117	159	160	118	76	34	ORANGE
BLUE	35	77	119	161	162	120	78	36	YELLOW
BLACK	37	79	121	163	164	122	80	38	BROWN
RED	39	81	123	165	166	124	82	40	ORANGE
BLUE	41	83	125	167	168	126	84	42	YELLOW



https://www.HaysElectrical.Com

THIS PRINT IS THE PROPERTY OF HAYS ELECTRICAL SERVICES. IT MUST NOT BE REPRODUCED IN ANY MANNER NOR SHALL IT BE SUBMITTED TO OUTSIDE PARTIES FOR EXAMINATION WITHOUT OUR CONSENT. IT SHALL BE USED ONLY AS A REFERENCE TO WORK DESIGNED OR FURNISHED BY US.

Project General Notes:
1. Rerise layout as needed base on SPECS/E.C. requirement
2. Installed junction box at accessible location for future service access.
3.
4.



Revision Schedule		Date
Number	Revision Title	
A	100% DESIGN DEVELOPMENT	9/30/26

100% DESIGN DEVELOPMENT
NOT FOR CONSTRUCTION

RAMBLER BATON ROUGE

BURBANK DR.
BATON ROUGE, LA

Project Number 26078
Date 09/30/26
Technician ALN
Superintendent WAW
Project Manager SS

LEVEL 2 EAST POWER
PLAN

Sheet Number

E122

9/30/2026 2:14:09 PM



1 LEVEL 2 EAST POWER PLAN
E122 3/32" = 1'-0"

GENERAL NOTES

- REFER TO SHEET E000 FOR ADDITIONAL GENERAL NOTES.
- ALL WIRING SHALL BE INSTALLED IN CONDUIT UNLESS NOTED OTHERWISE.
- ALL BRANCH CIRCUIT WIRING TO BE THIN INDOORS, AND XHHW-2 OUTDOORS (INCLUDING ON ROOF), UNLESS OTHERWISE NOTED.
- ALL BRANCH CIRCUITS TO INCLUDE GREEN EQUIPMENT GROUND.
- NO SHARED NEUTRALS, EACH NEUTRAL MUST BE IDENTIFIED FOR ITS PHASE.
- ALL RECEPTACLES IN WET LOCATIONS, WITHIN 6' OF A SINK OR OUTDOORS TO BE GFCI.

120/208V	SEC 1	SEC 2	SEC 3	SEC 4	SEC 3	SEC 1	277/480V
BLACK	1	43	85	127	128	86	44
RED	3	45	87	129	130	88	46
BLUE	5	47	89	131	132	90	48
BLACK	7	49	91	133	134	92	50
RED	9	51	93	135	136	94	52
BLUE	11	53	95	137	138	96	54
BLACK	13	55	97	139	140	98	56
RED	15	57	99	141	142	100	58
BLUE	17	59	101	143	144	102	60
BLACK	19	61	103	145	146	104	62
RED	21	63	105	147	148	106	64
BLUE	23	65	107	149	150	108	66
BLACK	25	67	109	151	152	110	68
RED	27	69	111	153	154	112	70
BLUE	29	71	113	155	156	114	72
BLACK	31	73	115	157	158	116	74
RED	33	75	117	159	160	118	76
BLUE	35	77	119	161	162	120	78
BLACK	37	79	121	163	164	122	80
RED	39	81	123	165	166	124	82
BLUE	41	83	125	167	168	126	84

THIS PRINT IS THE PROPERTY OF HAYS ELECTRICAL SERVICES. IT MUST NOT BE REPRODUCED IN ANY MANNER NOR SHALL IT BE SUBMITTED TO OUTSIDE PARTIES FOR EXAMINATION WITHOUT OUR CONSENT. IT SHALL BE USED ONLY AS A REFERENCE TO WORK DESIGNED OR FURNISHED BY US.

Project General Notes:
1. Rense layout as needed base on SPECS/N.E.C. requirement
2. Installed junction box at accessible location for future service access.
3.
4.

Revision Schedule			Date
Number	Revision Title		
A	100% DESIGN DEVELOPMENT		9/30/26

100% DESIGN DEVELOPMENT
NOT FOR CONSTRUCTION

RAMBLER BATON ROUGE

BURBANK DR.
BATON ROUGE, LA


Project Number 26078
Date 09/30/26
Technician ALN
Superintendent WAW
Project Manager SS

LEVEL 3 EAST POWER
PLAN

Sheet Number
E123

1. REFER TO SHEET E000 FOR ADDITIONAL GENERAL NOTES.
2. ALL WIRING SHALL BE INSTALLED IN CONDUIT UNLESS NOTED OTHERWISE.
3. ALL BRANCH CIRCUIT WIRING TO BE THHN INDOORS, AND XHHW-2 OUTDOORS (INCLUDING ON ROOF), UNLESS OTHERWISE NOTED.
4. ALL BRANCH CIRCUITS TO INCLUDE GREEN EQUIPMENT GROUND.
5. NO SHARED NEUTRALS. EACH NEUTRAL MUST BE IDENTIFIED FOR ITS PHASE.
6. ALL RECEPTACLES IN WET LOCATIONS, WITHIN 6' OF A SINK OR OUTDOORS TO BE GFCI.

12020BVC	SEC 1	SEC 2	SEC 3	SEC 4	SEC 4	SEC 5	SEC 2	SEC 1	277480V
BLACK	1	43	85	127	126	86	44	2	BROWN
RED	3	45	87	129	130	88	46	4	ORANGE
BLUE	5	47	89	131	132	90	48	6	YELLOW
RED	7	49	91	133	134	92	50	8	BROWN
BLUE	9	51	93	135	136	94	52	10	ORANGE
BLUE	11	53	95	137	138	96	54	12	YELLOW
BLACK	13	55	97	139	140	98	56	14	BROWN
RED	15	57	99	141	142	100	58	16	ORANGE
BLUE	17	59	101	143	144	102	60	18	YELLOW
BLACK	19	61	103	145	146	104	62	20	BROWN
RED	21	63	105	147	148	106	64	22	ORANGE
BLUE	23	65	107	149	150	108	66	24	YELLOW
BLACK	25	67	109	151	152	110	68	26	BROWN
RED	27	69	111	153	154	112	70	28	ORANGE
BLUE	29	71	113	155	156	114	72	30	YELLOW
BLACK	31	73	115	157	158	116	74	32	BROWN
RED	33	75	117	159	160	118	76	34	ORANGE
BLUE	35	77	119	161	162	120	78	36	YELLOW
BLACK	37	79	121	163	164	122	80	38	BROWN
RED	39	81	123	165	166	124	82	40	ORANGE
BLUE	41	83	125	167	168	126	84	42	YELLOW

 

THIS PRINT IS THE PROPERTY OF
HAYS ELECTRICAL SERVICES. IT
MUST NOT BE REPRODUCED IN ANY
MANNER NOR SHALL IT BE
SUBMITTED TO OUTSIDE PARTIES
FOR EXAMINATION WITHOUT OUR
CONSENT. IT SHALL BE USED ONLY
AS A REFERENCE TO WORK
DESIGNED OR FURNISHED BY US.

Project General Notes:

1. Revise layout as needed base on SPECS/N.E.C. requirement.
2. Installed junction box at accessible location for future service access.
- 3.
- 4.



	Revision Schedule	
Number	Revision Title	Date
A	100% DESIGN DEVELOPMENT	9/30/26

100% DESIGN DEVELOPMENT
NOT FOR CONSTRUCTION

RAMBLER BATON ROUGE

BURBANK DR.
BATON ROUGE, LA

Project Number	26078
Date	09/30/26
Technician	ALN
Superintendent	WAW
Project Manager	SS

LEVEL 4 EAST POWER PLAN

Sheet Number

E124

9/30/2026 2:14:28 PM

1 LEVEL 4 EAST POWER PLAN
E124 3/32" = 1'-0"

GENERAL NOTES

- REFER TO SHEET E000 FOR ADDITIONAL GENERAL NOTES.
- ALL WIRING SHALL BE INSTALLED IN CONDUIT UNLESS NOTED OTHERWISE.
- ALL BRANCH CIRCUIT WIRING TO BE THIN INDOORS, AND XHHW-2 OUTDOORS (INCLUDING ON ROOF), UNLESS OTHERWISE NOTED.
- ALL BRANCH CIRCUITS TO INCLUDE GREEN EQUIPMENT GROUND.
- NO SHARED NEUTRALS, EACH NEUTRAL MUST BE IDENTIFIED FOR ITS PHASE.
- ALL RECEPTACLES IN WET LOCATIONS, WITHIN 6' OF A SINK OR OUTDOORS TO BE GFCI.

120/208V	SEC 1	SEC 2	SEC 3	SEC 4	SEC 3	SEC 2	SEC 1	277/480V
BLACK	1	43	85	127	128	86	44	2 BROWN
RED	3	45	87	129	130	88	46	4 ORANGE
BLUE	5	47	89	131	132	90	48	6 YELLOW
BLACK	7	49	91	133	134	92	50	8 BROWN
RED	9	51	93	135	136	94	52	10 ORANGE
BLUE	11	53	95	137	138	96	54	12 YELLOW
BLACK	13	55	97	139	140	98	56	14 BROWN
RED	15	57	99	141	142	100	58	16 ORANGE
BLUE	17	59	101	143	144	102	60	18 YELLOW
BLACK	19	61	103	145	146	104	62	20 BROWN
RED	21	63	105	147	148	106	64	22 ORANGE
BLUE	23	65	107	149	150	108	66	24 YELLOW
BLACK	25	67	109	151	152	110	68	26 BROWN
RED	27	69	111	153	154	112	70	28 ORANGE
BLUE	29	71	113	155	156	114	72	30 YELLOW
BLACK	31	73	115	157	158	116	74	32 BROWN
RED	33	75	117	159	160	118	76	34 ORANGE
BLUE	35	77	119	161	162	120	78	36 YELLOW
BLACK	37	79	121	163	164	122	80	38 BROWN
RED	39	81	123	165	166	124	82	40 ORANGE
BLUE	41	83	125	167	168	126	84	42 YELLOW

THIS PRINT IS THE PROPERTY OF HAYS ELECTRICAL SERVICES. IT MUST NOT BE REPRODUCED IN ANY MANNER NOR SHALL IT BE SUBMITTED TO OUTSIDE PARTIES FOR EXAMINATION WITHOUT OUR CONSENT. IT SHALL BE USED ONLY AS A REFERENCE TO WORK DESIGNED OR FURNISHED BY US.

Project General Notes:
1. Raise layout as needed base on SPECS/A.E.C. requirement
2. Installed junction box at accessible location for future service access.
3.
4.

Revision Schedule		
Number	Revision Title	Date
A	100% DESIGN DEVELOPMENT	9/30/26

100% DESIGN DEVELOPMENT
NOT FOR CONSTRUCTION

RAMBLER BATON ROUGE

BURBANK DR.
BATON ROUGE, LA

Project Number 26078
Date 09/30/26
Technician ALN
Superintendent WAW
Project Manager SS

LEVEL 5 EAST POWER
PLAN

Sheet Number
E125

9/30/2026 2:14:37 PM

GENERAL NOTES

- REFER TO SHEET E000 FOR ADDITIONAL GENERAL NOTES.
- ALL WIRING SHALL BE INSTALLED IN CONDUIT UNLESS NOTED OTHERWISE.
- ALL BRANCH CIRCUIT WIRING TO BE THIN INDOORS, AND XHHW-2 OUTDOORS (INCLUDING ON ROOF), UNLESS OTHERWISE NOTED.
- ALL BRANCH CIRCUITS TO INCLUDE GREEN EQUIPMENT GROUND.
- NO SHARED NEUTRALS, EACH NEUTRAL MUST BE IDENTIFIED FOR ITS PHASE.
- ALL RECEPTACLES IN WET LOCATIONS, WITHIN 6' OF A SINK OR OUTDOORS TO BE GFCI.

120/208V	SEC 1	SEC 2	SEC 3	SEC 4	SEC 3	SEC 2	SEC 1	277/480V
BLACK	1	43	85	127	128	86	44	2 BROWN
RED	3	45	87	129	130	88	46	4 ORANGE
BLUE	5	47	89	131	132	90	48	6 YELLOW
BLACK	7	49	91	133	134	92	50	8 BROWN
RED	9	51	93	135	136	94	52	10 ORANGE
BLUE	11	53	95	137	138	96	54	12 YELLOW
BLACK	13	55	97	139	140	98	56	14 BROWN
RED	15	57	99	141	142	100	58	16 ORANGE
BLUE	17	59	101	143	144	102	60	18 YELLOW
BLACK	19	61	103	145	146	104	62	20 BROWN
RED	21	63	105	147	148	106	64	22 ORANGE
BLUE	23	65	107	149	150	108	66	24 YELLOW
BLACK	25	67	109	151	152	110	68	26 BROWN
RED	27	69	111	153	154	112	70	28 ORANGE
BLUE	29	71	113	155	156	114	72	30 YELLOW
BLACK	31	73	115	157	158	116	74	32 BROWN
RED	33	75	117	159	160	118	76	34 ORANGE
BLUE	35	77	119	161	162	120	78	36 YELLOW
BLACK	37	79	121	163	164	122	80	38 BROWN
RED	39	81	123	165	166	124	82	40 ORANGE
BLUE	41	83	125	167	168	126	84	42 YELLOW



https://www.HaysElectrical.Com

THIS PRINT IS THE PROPERTY OF HAYS ELECTRICAL SERVICES. IT MUST NOT BE REPRODUCED IN ANY MANNER NOR SHALL IT BE SUBMITTED TO OUTSIDE PARTIES FOR EXAMINATION WITHOUT OUR CONSENT. IT SHALL BE USED ONLY AS A REFERENCE TO WORK DESIGNED OR FURNISHED BY US.

Project General Notes:
1. Rense layout as needed base on SPECS/A.E.C. requirement
2. Installed Junction Box at accessible location for future service access.
3.
4.



Revision Schedule		
Number	Revision Title	Date
A	100% DESIGN DEVELOPMENT	9/30/26

100% DESIGN DEVELOPMENT
NOT FOR CONSTRUCTION

RAMBLER BATON ROUGE

BURBANK DR.
BATON ROUGE, LA

Project Number 26078
Date 09/30/26
Technician ALN
Superintendent WAW
Project Manager SS

LEVEL 6 EAST POWER
PLAN

Sheet Number

E126

9/30/2026 2:14:47 PM



1 LEVEL 6 EAST POWER PLAN
E126 3/32" = 1'-0"

GENERAL NOTES

- REFER TO SHEET E000 FOR ADDITIONAL GENERAL NOTES.
- ALL WIRING SHALL BE INSTALLED IN CONDUIT UNLESS NOTED OTHERWISE.
- ALL BRANCH CIRCUIT WIRING TO BE THIN INDOORS, AND XHHW-2 OUTDOORS (INCLUDING ON ROOF), UNLESS OTHERWISE NOTED.
- ALL BRANCH CIRCUITS TO INCLUDE GREEN EQUIPMENT GROUND.
- NO SHARED NEUTRALS. EACH NEUTRAL MUST BE IDENTIFIED FOR ITS PHASE.
- ALL RECEPTACLES IN WET LOCATIONS, WITHIN 6' OF A SINK OR OUTDOORS TO BE GFCI.

120/208V	SEC 1	SEC 2	SEC 3	SEC 4	SEC 4	SEC 3	SEC 2	SEC 1	277/480V
BLACK	1	43	85	127	128	86	44	2	BROWN
RED	3	45	87	129	130	88	46	4	ORANGE
BLUE	5	47	89	131	132	90	48	6	YELLOW
BLACK	7	49	91	133	134	92	50	8	BROWN
RED	9	51	93	135	136	94	52	10	ORANGE
BLUE	11	53	95	137	138	96	54	12	YELLOW
BLACK	13	55	97	139	140	98	56	14	BROWN
RED	15	57	99	141	142	100	58	16	ORANGE
BLUE	17	59	101	143	144	102	60	18	YELLOW
BLACK	19	61	103	145	146	104	62	20	BROWN
RED	21	63	105	147	148	106	64	22	ORANGE
BLUE	23	65	107	149	150	108	66	24	YELLOW
BLACK	25	67	109	151	152	110	68	26	BROWN
RED	27	69	111	153	154	112	70	28	ORANGE
BLUE	29	71	113	155	156	114	72	30	YELLOW
BLACK	31	73	115	157	158	116	74	32	BROWN
RED	33	75	117	159	160	118	76	34	ORANGE
BLUE	35	77	119	161	162	120	78	36	YELLOW
BLACK	37	79	121	163	164	122	80	38	BROWN
RED	39	81	123	165	166	124	82	40	ORANGE
BLUE	41	83	125	167	168	126	84	42	YELLOW

THIS PRINT IS THE PROPERTY OF HAYS ELECTRICAL SERVICES. IT MUST NOT BE REPRODUCED IN ANY MANNER NOR SHALL IT BE SUBMITTED TO OUTSIDE PARTIES FOR EXAMINATION WITHOUT OUR CONSENT. IT SHALL BE USED ONLY AS A REFERENCE TO WORK DESIGNED OR FURNISHED BY US.

Project General Notes:
1. Rense layout as needed base on SPECS/A.E.C. requirement
2. Installed junction box at accessible location for future service access.
3.
4.

Revision Schedule		
Number	Revision Title	Date
A	100% DESIGN DEVELOPMENT	9/30/26

100% DESIGN DEVELOPMENT
NOT FOR CONSTRUCTION

RAMBLER BATON ROUGE


BURBANK DR.
BATON ROUGE, LA

Project Number 26078
Date 09/30/26
Technician ALN
Superintendent WAW
Project Manager SS

EAST ROOF POWER PLAN

Sheet Number
E127

9/30/2026 2:14:52 PM

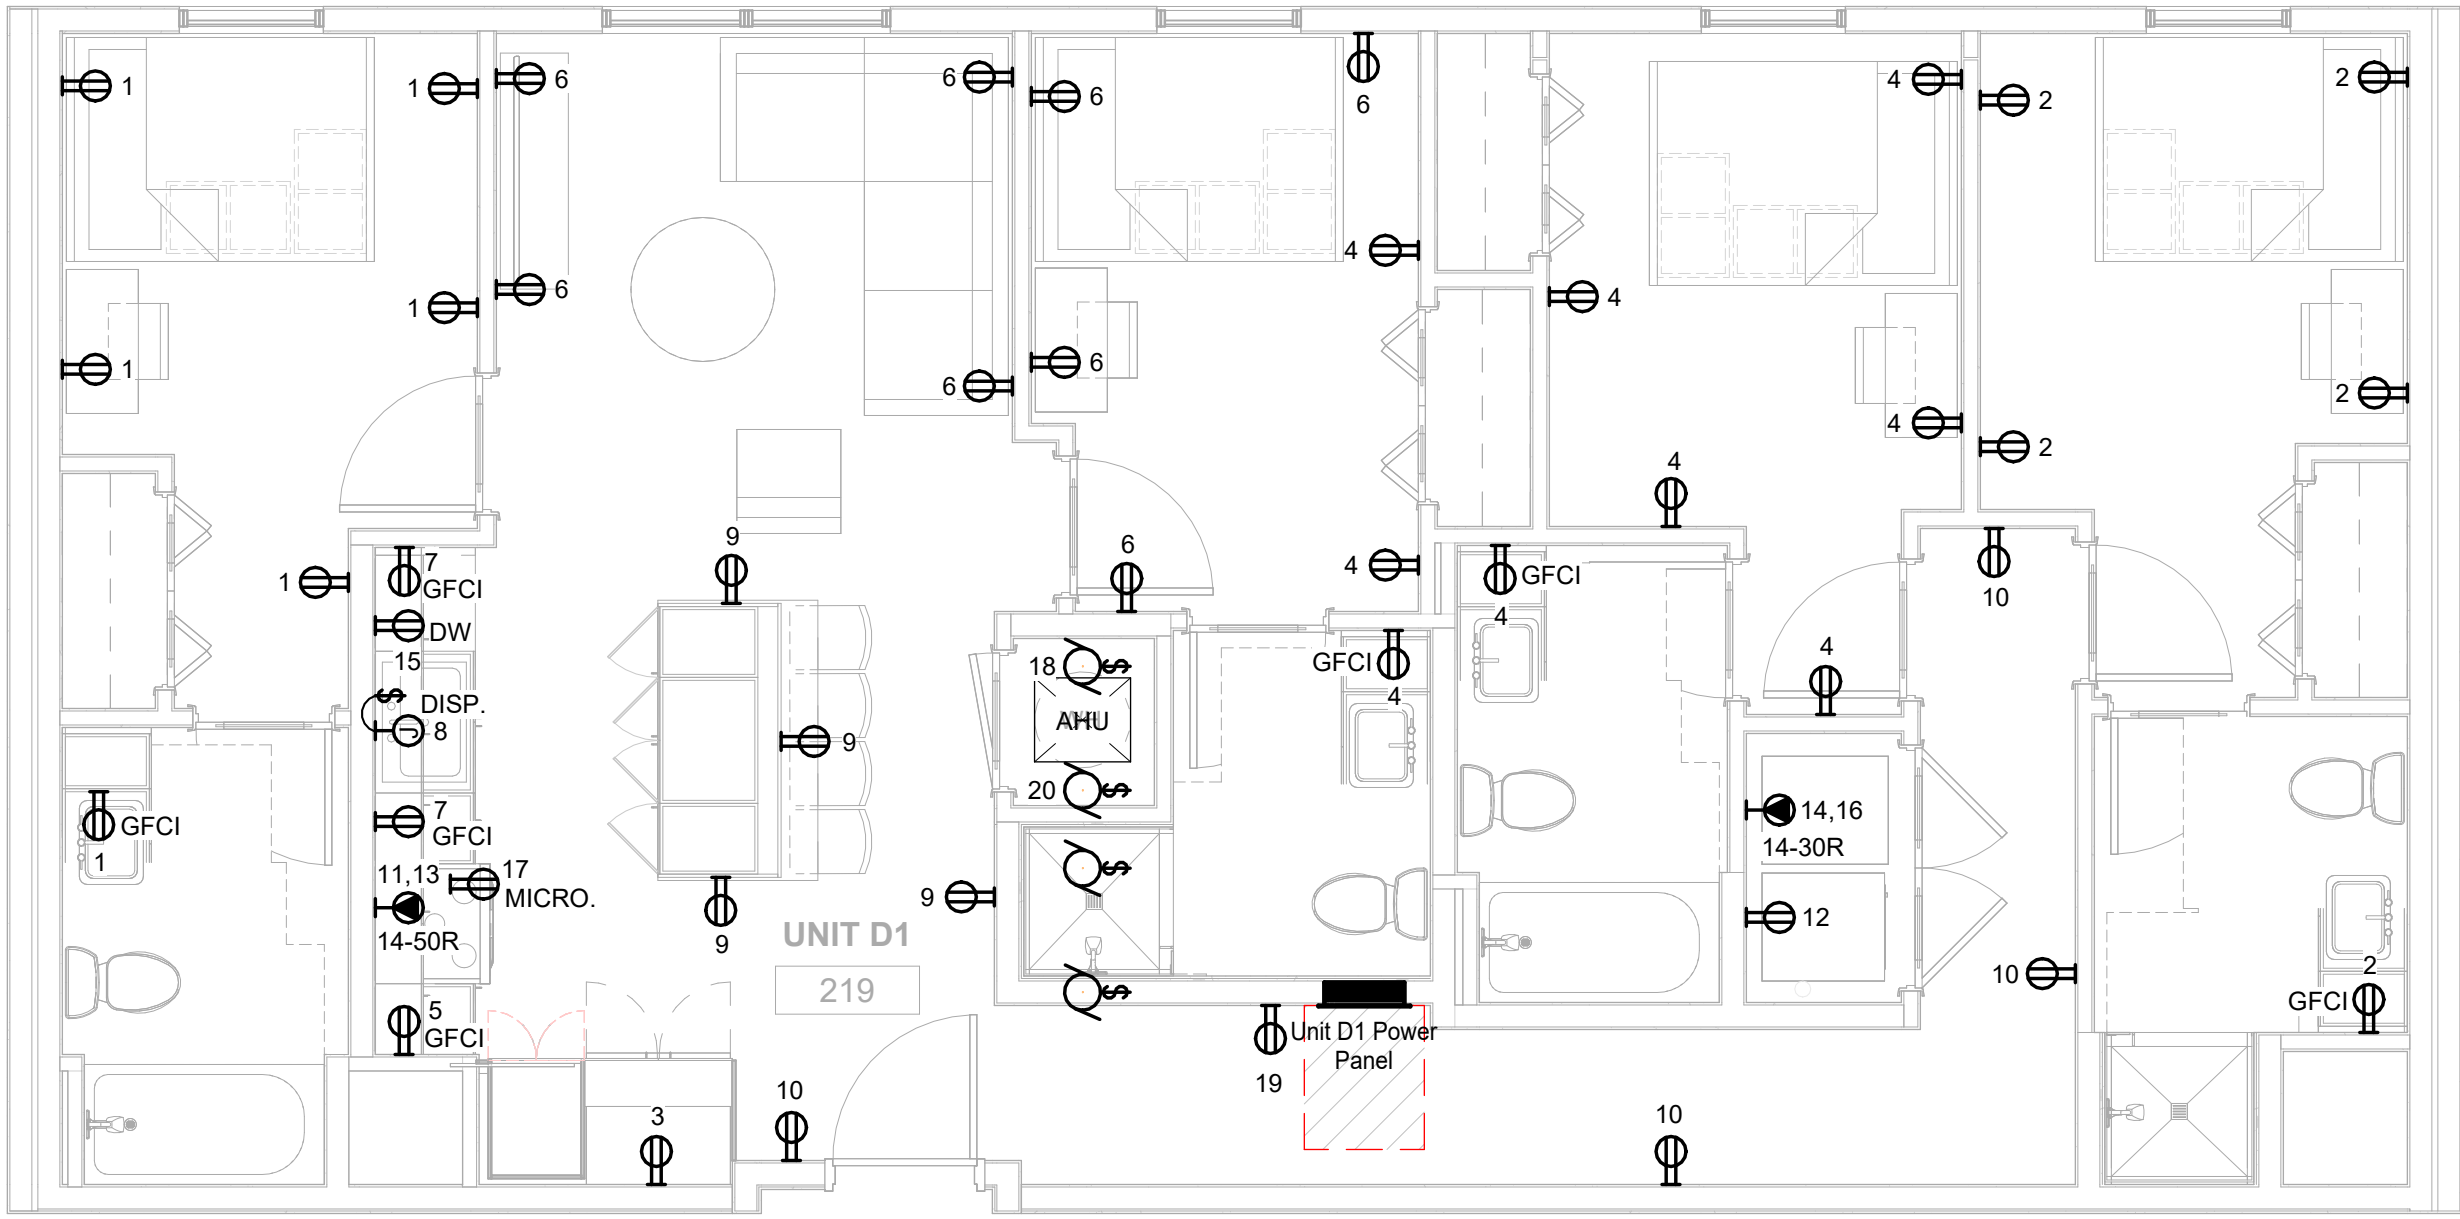

1 UNIT D1 - POWER PLAN
E400 1/4" = 1'-0"

PANELBOARD SCHEDULE										Unit D1 Power Panel									
MOUNTING: FLUSH					MAIN TYPE: MCB					MAIN RATING: 125 A									
FED FROM:					BUS					VOLTAGE					PHASE				
ENCLOSURE: NEMA 1					125 A					120/208 Single					1				
AIC RATING: 10 KAIC															WIRE				
															3				
PANEL ACCESSORIES:																			
CKT NO.	CIRCUIT DESIGNATION	AMPS	POLES	PHASE A LOAD	PHASE B LOAD	POLES	AMPS	CIRCUIT DESIGNATION	CKT NO.										
1	RCPTS - A BEDROOM & BATHROOM, 2	20	1	1.08	0.90			RCPTS - D BEDROOM & BATHROOM, 2	2										
3	RCPTS - REFRIGERATOR, 1,2	20	1		0.18	1.62	1	20	RCPTS - C BEDROOM & BATHROOM, 2										
5	RCPTS - KITCHEN COUNTER, 2	20	1	0.18	1.44			1	20	RCPTS - LIVING ROOM, 2									
7	RCPTS - KITCHEN COUNTER, 2	20	1		0.36	0.18	1	20	RCPT - GARBAGE DISPOSAL, 2										
9	RCPTS - KITCHEN & ISLAND, 2	20	1	0.72	0.72			1	20	RCPTS - UNIT CORRIDOR, 2									
11					4.16	0.18	1	20	RCPT - WASHING MACHINE, 2										
13	RANGE OVEN - NEMA 14-50R	50	2	4.16	2.50														
15	RCPT - DISHWASHER, 2	20	1		0.18	2.50	2	30	DRYER - NEMA 14-30R										
17	RCPT - MICROWAVE, 2	20	1	0.18	0.51			1	20	AIR HANDLER, 2									
19	RCPT - PANEL, 2	20	1		0.18	0.51	1	20	WATER HEATER, 2										
21	SPARE	20	1	0.00	0.00			1	20	SPARE									
23	SPARE	20	1		0.00	0.00	1	20	SPARE										
25	SPARE	20	1	0.00	0.00			1	20	SPARE									
27	SPARE	20	1		0.00	0.00	1	20	SPARE										
29	SPARE	20	1	0.00	0.00			1	20	SPARE									
31	SPARE	20	1		0.00	0.00	1	20	SPARE										
33	SPARE	20	1	0.00	0.00			1	20	SPARE									
35	SPARE	20	1		0.00	0.00	1	20	SPARE										
37	SPARE	20	1	0.00	0.00			1	20	SPARE									
39	SPARE	20	1		0.00	0.00	1	20	SPARE										
41	SPARE	20	1	0.00	0.00			1	20	SPARE									
		Total Load:		12.39 kVA		10.05 kVA													
		Total Amps:		103.22 A		83.72 A													
30 DAY METER DATA																			
Load Classification		Connected Load		Demand Factor		Estimated Demand		Panel Totals											
Motor		1.01 kVA		112.50%		1.14 kVA													
Receptacle		8.10 kVA		100.00%		8.10 kVA		CONN. LOAD TOTAL = 22.43 kVA											
Kitchen Equipment - Dwelling Unit		8.32 kVA		80.00%		6.66 kVA		DEMAND LOAD TOTAL = 20.89 kVA											
Household Dryers		5.00 kVA		100.00%		5.00 kVA		CONN. AMPS TOTAL = 107.85 A											
								DEMAND AMPS TOTAL = 100.45 A											

120/208V	SEC 1	SEC 2	SEC 3	SEC 4	SEC 4	SEC 3	SEC 2	SEC 1	277/480V
BLACK	1	43	85	127	128	86	44	2	BROWN
RED	3	45	87	129	130	88	46	4	ORANGE
BLUE	5	47	89	131	132	90	48	6	YELLOW
BLACK	7	49	91	133	134	92	50	8	BROWN
RED	9	51	93	135	136	94	52	10	ORANGE
BLUE	11	53	95	137	138	96	54	12	YELLOW
BLACK	13	55	97	139	140	98	56	14	BROWN
RED	15	57	99	141	142	100	58	16	ORANGE
BLUE	17	59	101	143	144	102	60	18	YELLOW
BLACK	19	61	103	145	146	104	62	20	BROWN
RED	21	63	105	147	148	106	64	22	ORANGE
BLUE	23	65	107	149	150	108	66	24	YELLOW
BLACK	25	67	109	151	152	110	68	26	BROWN
RED	27	69	111	153	154	112	70	28	ORANGE
BLUE	29	71	113	155	156	114	72	30	YELLOW
BLACK	31	73	115	157	158	116	74	32	BROWN
RED	33	75	117	159	160	118	76	34	ORANGE
BLUE	35	77	119	161	162	120	78	36	YELLOW
BLACK	37	79	121	163	164	122	80	38	BROWN
RED	39	81	123	165	166	124	82	40	ORANGE
BLUE	41	83	125	167	168	126	84	42	YELLOW

GENERAL NOTES

- REFER TO SHEET E000 FOR ADDITIONAL GENERAL NOTES.
- ALL WIRING SHALL BE INSTALLED IN CONDUIT UNLESS NOTED OTHERWISE.
- ALL BRANCH CIRCUIT WIRING TO BE THHN INDOORS, AND XHHW-2 OUTDOORS (INCLUDING ON ROOF), UNLESS OTHERWISE NOTED.
- ALL BRANCH CIRCUITS TO INCLUDE GREEN EQUIPMENT GROUND.
- NO SHARED NEUTRALS. EACH NEUTRAL MUST BE IDENTIFIED FOR ITS PHASE.
- ALL RECEPTACLES IN WET LOCATIONS, WITHIN 6' OF A SINK OR OUTDOORS TO BE GFCI.

Project General Notes:
1. Rerise layout as needed base on SPECS & I.E.C. requirement
2. Installed Junction box at accessible location for future service access.
3.
4.

Revision Schedule		Date
Number	Revision Title	
A	100% DESIGN DEVELOPMENT	9/30/26

100% DESIGN DEVELOPMENT
NOT FOR CONSTRUCTION

RAMBLER BATON ROUGE

BURBANK DR.
BATON ROUGE, LA

Project Number 26078

Date 09/30/26

Technician BKS

Superintendent WAW

Project Manager SS

ENLARGED ELECTRICAL
ROOM D1 PLANS

Sheet Number

E400

THIS PRINT IS THE PROPERTY OF HAYS ELECTRICAL SERVICES. IT MUST NOT BE REPRODUCED IN ANY MANNER NOR SHALL IT BE SUBMITTED TO OUTSIDE PARTIES FOR EXAMINATION WITHOUT OUR CONSENT. IT SHALL BE USED ONLY AS A REFERENCE TO WORK DESIGNED OR FURNISHED BY US.

Project General Notes:
1. Revised layout as needed base on SPEC'S & I.E.C. requirement
2. Installed Junction box at accessible location for future service access.
3.
4.

Revision Schedule		Date	Revision Title	100% DESIGN DEVELOPMENT					
△	Number	A							

100% DESIGN DEVELOPMENT
NOT FOR CONSTRUCTION

RAMBLER BATON ROUGE

BURBANK DR.
BATON ROUGE, LA

Project Number 26078

Date 09/30/2026

Technician C.J.H

Superintendent WAW

Project Manager SS

PANELBOARD SCHEDULES

PANELBOARD SCHEDULE					PANEL DESIGNATION:		MSB1W	
MAIN	3000A	VOLTAGE		480	LOCATION:	WEST BUILDING		
MTG	PAD MOUNTED			277	FEATURES:	3000A MAIN BREAKER W/LSI ELECTRONIC TRIP UNIT W/ INTEGRAL POWER SUPPLY FOR LCD DISPLAY, LSI ADJUSTABLE FEEDER BREAKERS, INTEGRAL 250KA SURGE PROTECTION DEVICE.		
TYPE	BREAKER	PHASE	3					
ENCL.	NEMA 1	WIRES	4					
A.I.C.	65,000 RMS	AMPS	3000					
CCT #	CIRCUIT DESCRIPTION	AMPOLE	KVA	Ø	KVA	AMPOLE	CIRCUIT DESCRIPTION	CCT #
1				A				2
3	MC-1A TRANSFORMER	350/3		B		350/3	MC-1B TRANSFORMER	4
5				C				6
7				A				8
9	MC-1C TRANSFORMER	350/3		B		350/3	MC-3A TRANSFORMER	10
11				C				12
13				A				14
15	MC-3B TRANSFORMER	800/3		B		800/3	MC-3C TRANSFORMER	16
17				C				18
19				A				20
21	MC-5A TRANSFORMER	350/3		B		800/3	MC-5B TRANSFORMER	22
23				C				24
25				A				26
27	MC-5C TRANSFORMER	800/3		B		350/3	MC-6C TRANSFORMER	28
29				C				30
31				A				32
33	SPACE			B			SPACE	34
35				C				36
37				A				38
39	SPACE			B			SPACE	40
41				C				42
43				A				44
45	SPACE			B			SPACE	46
47				C				48
49				A				50
51	SPACE			B			SPACE	52
53				C				54
55				A		60/3	SPD	56
57	SPACE			B				58
59				C				60
		LEFT SIDE KVA	0.0		0.0	RIGHT SIDE KVA		
			Ø A KVA	0.0			TOTAL KVA	0.0
			Ø B KVA	0.0			TOTAL AMPS	0.0
			Ø C KVA	0.0				

PANELBOARD SCHEDULE				PANEL DESIGNATION:			HP-2W	
MAIN	NONE	VOLTAGE	480	LOCATION	WEST BUILDING 2ND FLOOR			
MTG	SURFACERACK		277	FEATURES:	SQUARED TYPE NF PANELBOARD.			
TYPE	MLO	PHASE	3					
ENCL.	NEMA 1	WIRES	4					
A.I.C.	35,000 RMS	AMPS	125					
CCT #	CIRCUIT DESCRIPTION	AMPS	KVA	Ø	AMPS	CIRCUIT DESCRIPTION	CCT #	
1	LP-2W TRANSFORMER	70/3		A	20/1	SPARE	2	
3			B	20/1	SPARE	4		
5			C	20/1	SPARE	6		
7			A			8		
9			B			10		
11			C			12		
13			A			14		
15			B			16		
17			C			18		
LEFT SIDE KVA			0.0	0.0	RIGHT SIDE KVA			
		Ø A KVA	0.0			TOTAL KVA:	0.0	
		Ø B KVA	0.0			TOTAL AMPS:	0.0	
		Ø C KVA	0.0					


PANELBOARD SCHEDULE				PANEL DESIGNATION:				LP-2W	
MAIN	150A	VOLTAGE		208	LOCATION	WEST BUILDING, 2ND FLOOR			
MTG	SURFACE RACK			120	FEATURES	SQUARE D TYPE NF PANELBOARD			
TYPE	BREAKER	PHASE	3						
ENCL.	NEMA 1	WIRES	4						
A.I.C.	14,000 RMS	AMPS	150						
CCT #	CIRCUIT DESCRIPTION		AMPS	KVA	Ø	KVA	AMPS	CIRCUIT DESCRIPTION	CCT #
1	RECEPTS - NORTH HALLWAY		20/1		A	20/1		LIGHTS - NORTH HALLWAY	2
3	RECEPTS - CENTER HALLWAY		20/1		B	20/1		LIGHTS - CENTER HALLWAY	4
5	RECEPTS - SOUTH HALLWAY		20/1		C	20/1		LIGHTS - SOUTH HALLWAY	6
7	RECEPTS - WEST HALLWAY		20/1		A	20/1		LIGHTS - WEST HALLWAY	8
9	RECEPTS - EAST HALLWAY		20/1		B	20/1		LIGHTS - EAST HALLWAY	10
11	DEDICATED RECEPT - UTIL RM 1		15/1		C	30/2		IDF CLOSET RACK 1	12
13	DEDICATED RECEPT - UTIL RM 2		15/1		A				14
15	DEDICATED RECEPT - UTIL RM 3		15/1		B	30/2		IDF CLOSET RACK 2	16
17	DEDICATED RECEPT - UTIL RM 4		15/1		C				18
19	DEDICATED RECEPT - UTIL RM 5		15/1		A	20/1		SPARE	20
21	DEDICATED RECEPT - UTIL RM 6		15/1		B	20/1		SPARE	22
23	DEDICATED RECEPT - UTIL RM 7		15/1		C	20/1		SPARE	24
25	DEDICATED RECEPT - UTIL RM 8		15/1		A	20/1		SPARE	26
27	DEDICATED RECEPT - UTIL RM 9		15/1		B	20/1		SPARE	28
29	SPACE				C	20/1		SPARE	30
				LEFT SIDE KVA		0.0	RIGHT SIDE KVA		0.0
				Ø A KVA		0.0			TOTAL KVA
				Ø B KVA		0.0			TOTAL AMPS
				Ø C KVA		0.0			0.0

PANELBOARD SCHEDULE				PANEL DESIGNATION:				MSB2W	
MAIN	3000A	VOLTAGE		480	LOCATION	WEST BUILDING			
MTG	PAD MOUNTED			277	FEATURES:	3000A MAIN BREAKER W/LSI ELECTRONIC TRIP UNIT W/ INTEGRAL POWER SUPPLY FOR LCD DISPLAY, INTEGRAL 250KA SURGE PROTECTION DEVICE.			
TYPE	BREAKER	PHASE		3					
ENCL.	NEMA 1	WIRES		4					
A.I.C.	65,000 RMS	AMPS		3000					
CCT #	CIRCUIT DESCRIPTION	AMPS	KVA	Ø	KVA	AMPS	CIRCUIT DESCRIPTION	CCT #	
1				A				2	
3	HP-P1W	100/3		B		100/3	HP-P2W	4	
5				C				6	
7				A				8	
9	HP-P3W	100/3		B		100/3	HP-P4W	10	
11				C				12	
13				A				14	
15	HP-P5W	100/3		B		100/3	HP-P6W	16	
17				C				18	
19				A				20	
21	HP-P7W	100/3		B		400/3	MCC-GW	22	
23				C				24	
25				A				26	
27	HP-AW	400/3		B		400/3	HP-RW	28	
29				C				30	
31				A				32	
33	T-1W	225/3		B		225/3	T-CAFE	34	
35				C				36	
37				A				38	
39	HP-2W	100/3		B		100/3	HP-3W	40	
41				C				42	
43				A				44	
45	HP-4W	100/3		B		100/3	HP-5W	46	
47				C				48	
49				A				50	
51	HP-6W	100/3		B		225/3	HP-MW	52	
53				C				54	
55				A				56	
57	ATS-1W	400A		B				58	
59				C		60/3	SPD	60	
61				A				62	
63	SPACE			B				64	
65				C				66	
		LEFT SIDE KVA	0.0		0.0	RIGHT SIDE KVA			
		Ø A KVA	0.0					TOTAL KVA: 0.0	
		Ø B KVA	0.0					TOTAL AMPS: 0.0	
		Ø C KVA	0.0						


PANELBOARD SCHEDULE				PANEL DESIGNATION:				MSB1E			
MAIN	3000A	VOLTAGE		208	LOCATION	EAST BUILDING					
MTG	PAD MOUNTED			120	FEATURES:	3000A MAIN BREAKER W/LSI ELECTRONIC TRIP UNIT W/ INTEGRAL POWER SUPPLY FOR LCD DISPLAY, LSI ADJUSTABLE FEEDER BREAKERS, INTEGRAL 250KA SURGE PROTECTION DEVICE.					
TYPE	BREAKER	PHASE	3								
ENCL.	NEMA 1	WIRES	4								
A.I.C.	65,000 RMS	AMPS	3000								
CCT #	CIRCUIT DESCRIPTION	AMPS/POLE	KVA	Ø	KVA	AMPS/POLE	CIRCUIT DESCRIPTION	CCT #			
1				A				2			
3	MC-1B	400/3		B		1000/3	MC-2A	4			
5				C				6			
7				A				8			
9	MC-2B	1000/3		B		1000/3	MC-4A	10			
11				C				12			
13				A				14			
15	MC-4B	1000/3		B		600/3	MC-6A	16			
17				C				18			
19				A				20			
21	MC-6B	600/3		B			SPACE	22			
23				C				24			
25				A				26			
27	SPACE			B			SPACE	28			
29				C				30			
31				A				32			
33	SPACE			B			SPACE	34			
35				C				36			
37				A				38			
39	SPACE			B			SPACE	40			
41				C				42			
43				A				44			
45	SPACE			B			SPACE	46			
47				C				48			
49				A				50			
51	SPACE			B			SPACE	52			
53				C				54			
55				A			SPD	56			
57	SPACE			B		60/3		58			
59				C				60			
		LEFT SIDE KVA	0.0		0.0	RIGHT SIDE KVA					
		Ø A KVA	0.0				TOTAL KVA	0.0			
		Ø B KVA	0.0				TOTAL AMPS	0.0			
		Ø C KVA	0.0								

PANELBOARD SCHEDULE				PANEL DESIGNATION:				HP-2E	
MAIN	NONE	VOLTAGE	480	LOCATION	EAST BUILDING, 2ND FLOOR				
MTG	SURFACE/RACK		277	FEATURES:	SQUARE D TYPE NF PANELBOARD.				
TYPE	MLO	PHASE	3						
ENCL.	NEMA 1	WIRES	4						
A.I.C.	35,000 RMS	AMPS	125						
CCT #	CIRCUIT DESCRIPTION	AMPS	Ø	KVA	AMPS	CIRCUIT DESCRIPTION	CCT #		
1	LP-2E TRANSFORMER	70/3	A		20/1	SPARE	2		
3			B		20/1	SPARE	4		
5			C		20/1	SPARE	6		
7							8		
9		B				10			
11		C				12			
13		A				14			
15		B				16			
17		C				18			
		LEFT SIDE KVA	0.0	0.0	RIGHT SIDE KVA				
		Ø A KVA	0.0		Ø A KVA	0.0	TOTAL KVA:	0.0	
		Ø B KVA	0.0		Ø B KVA	0.0	TOTAL AMPS:	0.0	
		Ø C KVA	0.0		Ø C KVA	0.0			

PANELBOARD SCHEDULE				PANEL DESIGNATION:				LP-2E	
MAIN	150A	VOLTAGE		208	LOCATION	EAST BUILDING, 2ND FLOOR			
MTG	SURFACERACK			120	FEATURES:	SQUARE D TYPE NF PANELBOARD			
INTG	BREAKER	PHASE	3						
A/C	NEMA 1	WRES	4						
A/C	14,000 RMS	AMPS	150						
CCT #	CIRCUIT DESCRIPTION		AMPS/FA	Ø	KVA	AMPS/FA	CIRCUIT DESCRIPTION		CCT #
1	RECEPTS - NORTH HALLWAY		201	A	201	LIGHTS - NORTH HALLWAY		2	
3	RECEPTS - CENTER HALLWAY		201	B	201	LIGHTS - CENTER HALLWAY		4	
5	RECEPTS - SOUTH HALLWAY		201	C	201	LIGHTS - SOUTH HALLWAY		6	
7	RECEPTS - WEST HALLWAY		201	A	201	LIGHTS - WEST HALLWAY		8	
9	RECEPTS - EAST HALLWAY		201	B	201	LIGHTS - EAST HALLWAY		10	
11	DEDICATED RECEPT - UTIL RM 1		151	C	302	IDF CLOSET RACK 1		12	
13	DEDICATED RECEPT - UTIL RM 2		151	A	302	IDF CLOSET RACK 1		14	
15	DEDICATED RECEPT - UTIL RM 3		151	B	302	IDF CLOSET RACK 2		16	
17	DEDICATED RECEPT - UTIL RM 4		151	C	302	IDF CLOSET RACK 2		18	
19				A	201	SPARE		20	
21				B	201	SPARE		22	
23				C	201	SPARE		24	
25				A	201	SPARE		26	
27				B	201	SPARE		28	
29	SPACE			C	201	SPARE		30	
LEFT SIDE KVA			0.0	0.0	RIGHT SIDE KVA				
Ø A KVA			0.0					TOTAL KVA	
Ø B KVA			0.0					TOTAL AMPS	
Ø C KVA			0.0					0.0	

 

1. Revise layout as needed base on SPECS/N.E.C. requirement.
2. Installed junction box at accessible location for future service access.

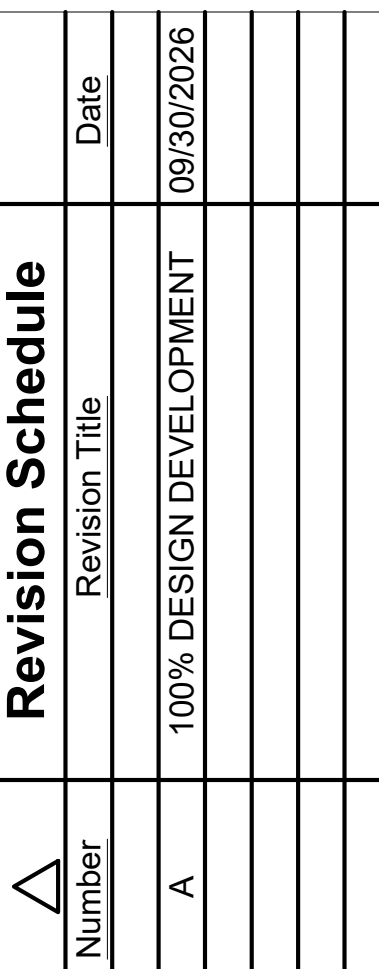

AMBLER BATON ROUGE

Project Number	26078
----------------	-------

ate 09/30/2026

technician CJH


superintendent WAW

Project Manager	SS
-----------------	----

NE-LINE - WEST HOUSE

Sheet Number **E700**

17/2026 4:54:41 PM

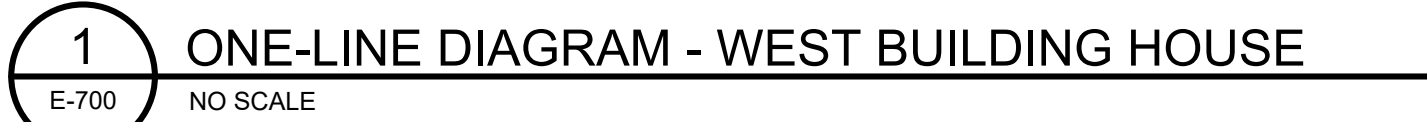


ONE-LINE GENERAL NOTES:

- A. UNLESS OTHERWISE NOTED, EQUIPMENT SHOWN WITH LIGHT SHADED LINES AND / OR DESIGNATED WITH AN 'X' INDICATES EXISTING AND SHALL REMAIN.
- B. ALL CABLE LENGTHS ARE ESTIMATED AND SHALL BE USED AS A REFERENCE ONLY. CONTRACTOR SHALL FIELD VERIFY ACTUAL LENGTHS AND RESIZE CONDUCTORS AS REQUIRED TO MEET THE AMPACITY, DE-RATING, AND VOLTAGE DROP REQUIREMENTS OF THE NPFA NATIONAL ELECTRICAL CODE (NEC) FOR EFFICIENCY CODES. SUBMIT ALL INSTALLATION WIRE LENGTHS AND FIELD CHANGES TO THE OWNER AND ENGINEER.
- C. CONTRACTOR SHALL FIELD VERIFY THE ACTUAL EQUIPMENT NAMEPLATE DATA AND SUBMIT ALL DATA TO THE OWNER AND ENGINEER.
- D. SHORT CIRCUIT CURRENT (SCC) VALUES ARE BASED ON THE WORST CASE SCENARIO. DATA SHALL NOT BE USED FOR ARC FLASH CALCULATIONS.
- E. PROVIDE LABELING FOR ALL ELECTRICAL EQUIPMENT INCLUDING EXISTING EQUIPMENT INVOLVED IN PROJECT. SEE LABELING DETAIL SHEET E020-E004.
- F. CONTRACTOR SHALL NOT USE SUBSTITUTIONS OR EQUIVALENTS FOR THE PANELBOARDS, CIRCUIT BREAKERS, SURGE PROTECTION DEVICES, OR OTHER EQUIPMENT LISTED ON THIS SHEET.
- G. NEUTRAL AND GROUNDING CONDUCTORS SHALL BE SEPARATED AND TERMINATED ON THEIR DESIGNATED TERMINATION BAR IN EVERY PANEL.
- H. CONTRACTOR SHALL TORQUE ALL CONNECTIONS PER THE MANUFACTURER'S REQUIREMENTS. THE ACTUAL FIELD VALUES SHALL BE DOCUMENTED AND PROVIDED TO THE OWNER. FIELD VERIFY THE MANUFACTURER, SIZE, AND TYPE OF ALL CIRCUIT BREAKERS INSTALLED IN ALL EQUIPMENT. PROVIDE THE DATA TO THE OWNER AND ENGINEER.
- I. BREAKERS ARE SHIPPED WITH FACTORY SETTINGS. OBTAIN BREAKER SETTINGS FROM ENGINEER AND ADJUST ACCORDINGLY.
- J. ALL WORK SHALL COMPLY WITH GENERAL NOTES ON SHEET E001.
- K. REFER TO PLANS, SCHEDULES, AND SPECIFICATIONS FOR ADDITIONAL EQUIPMENT INFORMATION.

ONE-LINE GENERAL NOTES:

- A. UNLESS OTHERWISE NOTED, EQUIPMENT SHOWN WITH LIGHT SHADED LINES AND / OR DESIGNATED WITH AN 'X' INDICATES EXISTING AND SHALL REMAIN.
- B. ALL CABLE LENGTHS ARE ESTIMATED AND SHALL BE USED AS A REFERENCE ONLY. CONTRACTOR SHALL FIELD VERIFY ACTUAL LENGTHS AND RESIZE CONDUCTORS AS REQUIRED TO MEET THE AMPACITY, DE-RATING, AND VOLTAGE DROP REQUIREMENTS OF THE NFPA NATIONAL ELECTRICAL CODE (NEC) AND ENERGY EFFICIENCY CODES. SUBMIT ALL INSTALLED WIRE LENGTHS AND FIELD CHANGES TO THE OWNER AND ENGINEER.
- C. CONTRACTOR SHALL FIELD VERIFY THE ACTUAL EQUIPMENT NAMEPLATE DATA AND SUBMIT ALL DATA TO THE OWNER AND ENGINEER.
- D. SHORT CIRCUIT CURRENT (SCC) VALUES ARE BASED ON THE WORST CASE SCENARIO. DATA SHALL NOT BE USED FOR ARC FLASH CALCULATIONS.
- E. PROVIDE LABELING FOR ALL ELECTRICAL EQUIPMENT INCLUDING EXISTING EQUIPMENT INVOLVED IN PROJECT. SEE LABELING DETAIL SHEETS E002-E004.
- F. CONTRACTOR SHALL NOT USE SUBSTITUTIONS OR EQUIVALENTS FOR THE PANELBOARDS, CIRCUIT BREAKERS, SURGE PROTECTION DEVICES, OR OTHER EQUIPMENT LISTED ON THIS SHEET.
- G. NEUTRAL AND GROUNDING CONDUCTORS SHALL BE SEPARATED AND TERMINATED ON THEIR DESIGNATED TERMINATION BAR IN EVERY PANEL.
- H. CONTRACTOR SHALL TORQUE ALL CONNECTIONS PER THE MANUFACTURER'S REQUIREMENTS. THE ACTUAL FIELD VALUES SHALL BE DOCUMENTED AND PROVIDED TO THE OWNER.
- I. FIELD VERIFY THE MANUFACTURER, SIZE, AND TYPE OF FUSES / BREAKERS INSTALLED IN ALL EQUIPMENT. PROVIDE THE DATA TO THE OWNER AND ENGINEER.
- J. BREAKERS ARE SHIPPED WITH FACTORY SETTINGS. OBTAIN BREAKER SETTINGS FROM ENGINEER AND ADJUST ACCORDINGLY.
- K. ALL WORK SHALL COMPLY WITH GENERAL NOTES ON SHEET E001.
- L. REFER TO PLANS, SCHEDULES, AND SPECIFICATIONS FOR ADDITIONAL EQUIPMENT INFORMATION.

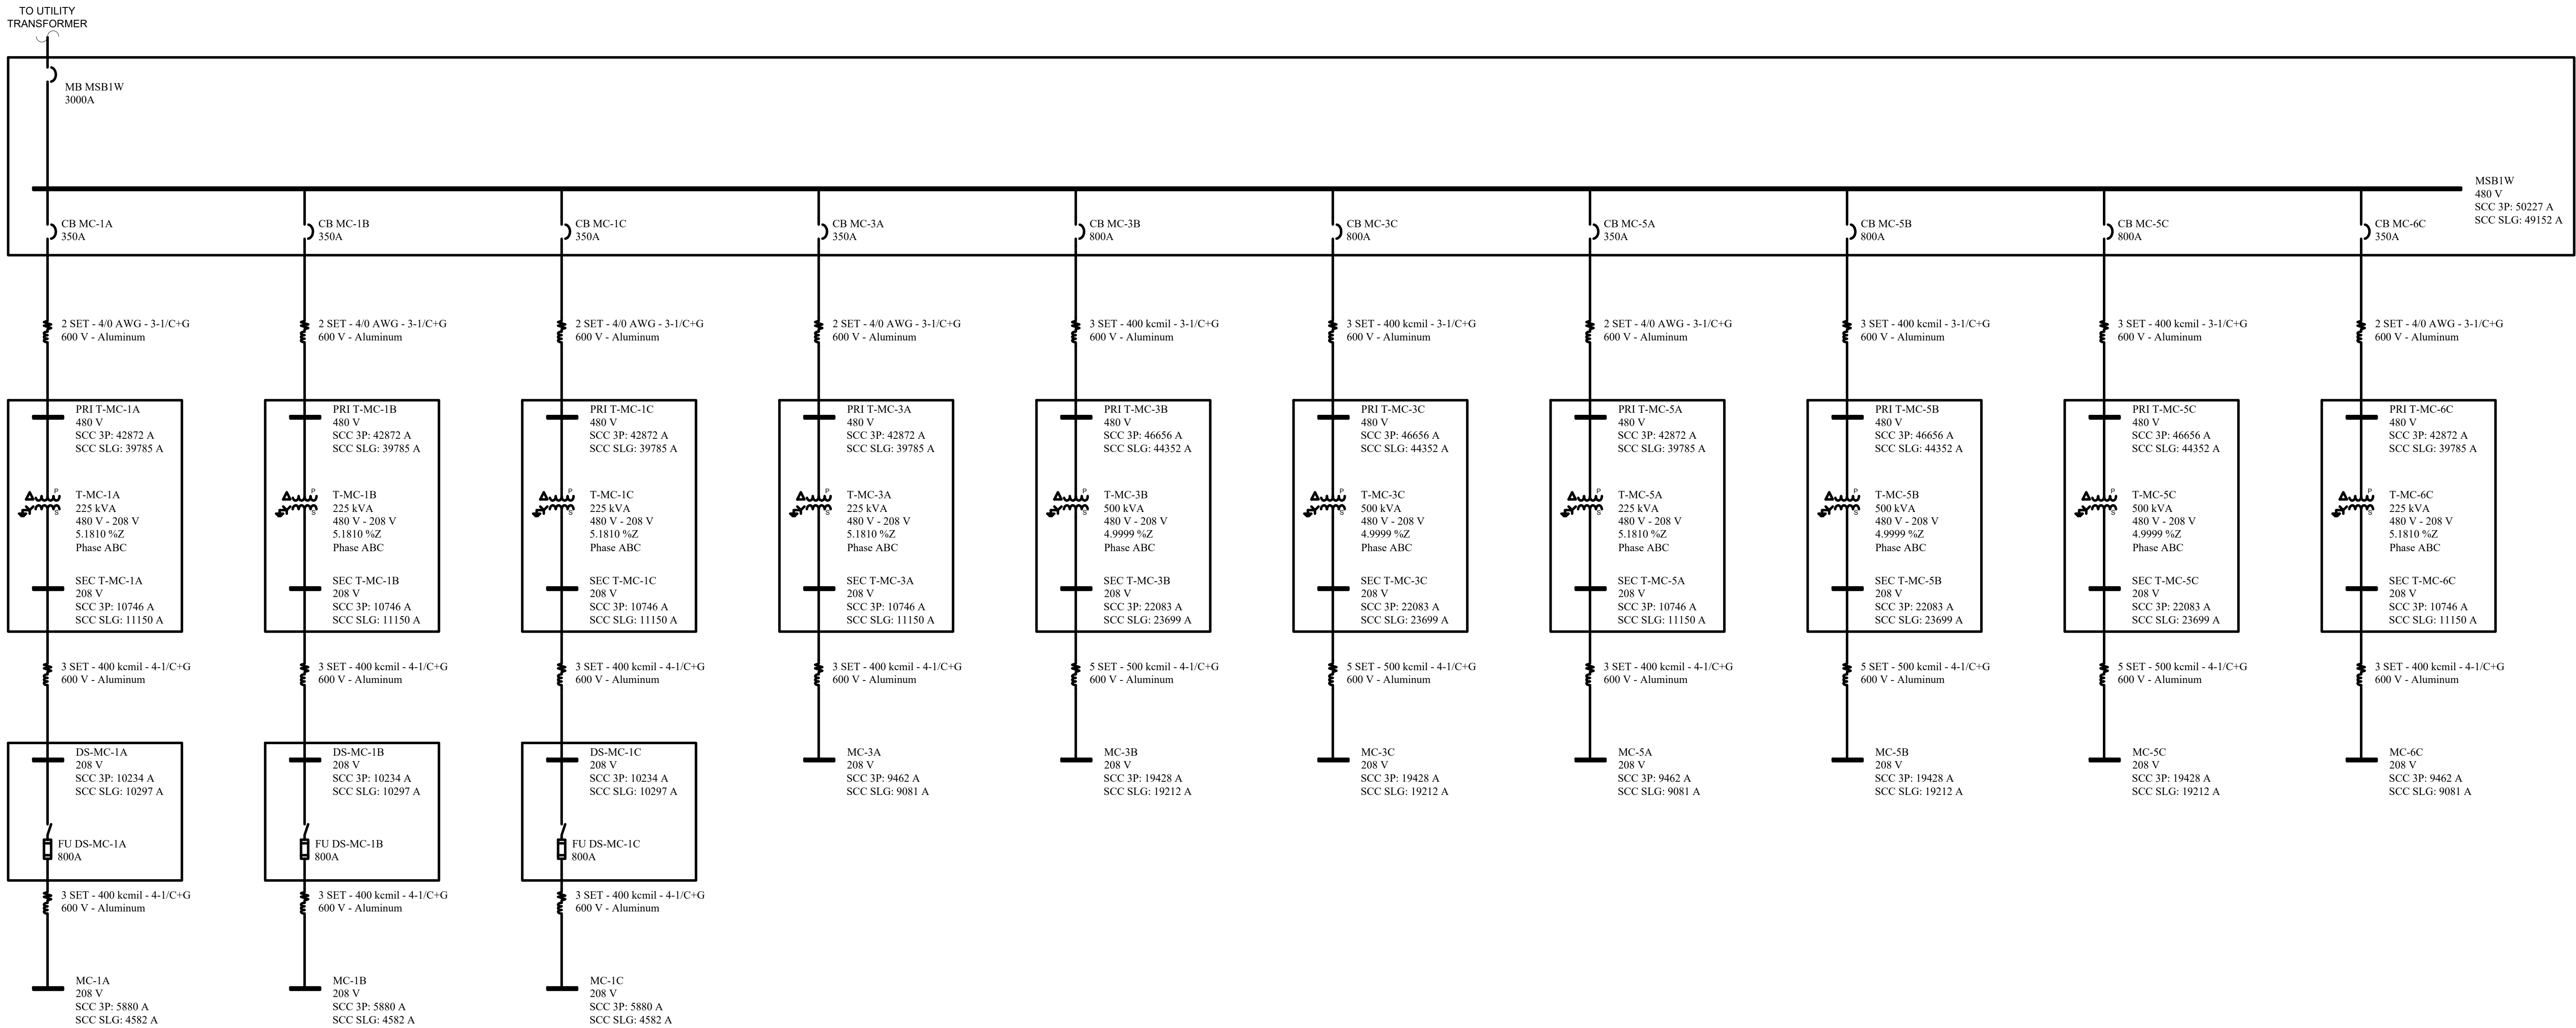

1 ONE-LINE DIAGRAM - WEST BUILDING DOMICILES
E-701 NO SCALE

100% DESIGN DEVELOPMENT
NOT FOR CONSTRUCTION

RAMBLER BATON ROUGE

BURBANK DR.
BATON ROUGE, LA

Project Number 26078


Date 09/30/2026

Technician CJH


Superintendent WAW

Project Manager SS

ONE-LINE - WEST DOMICILE

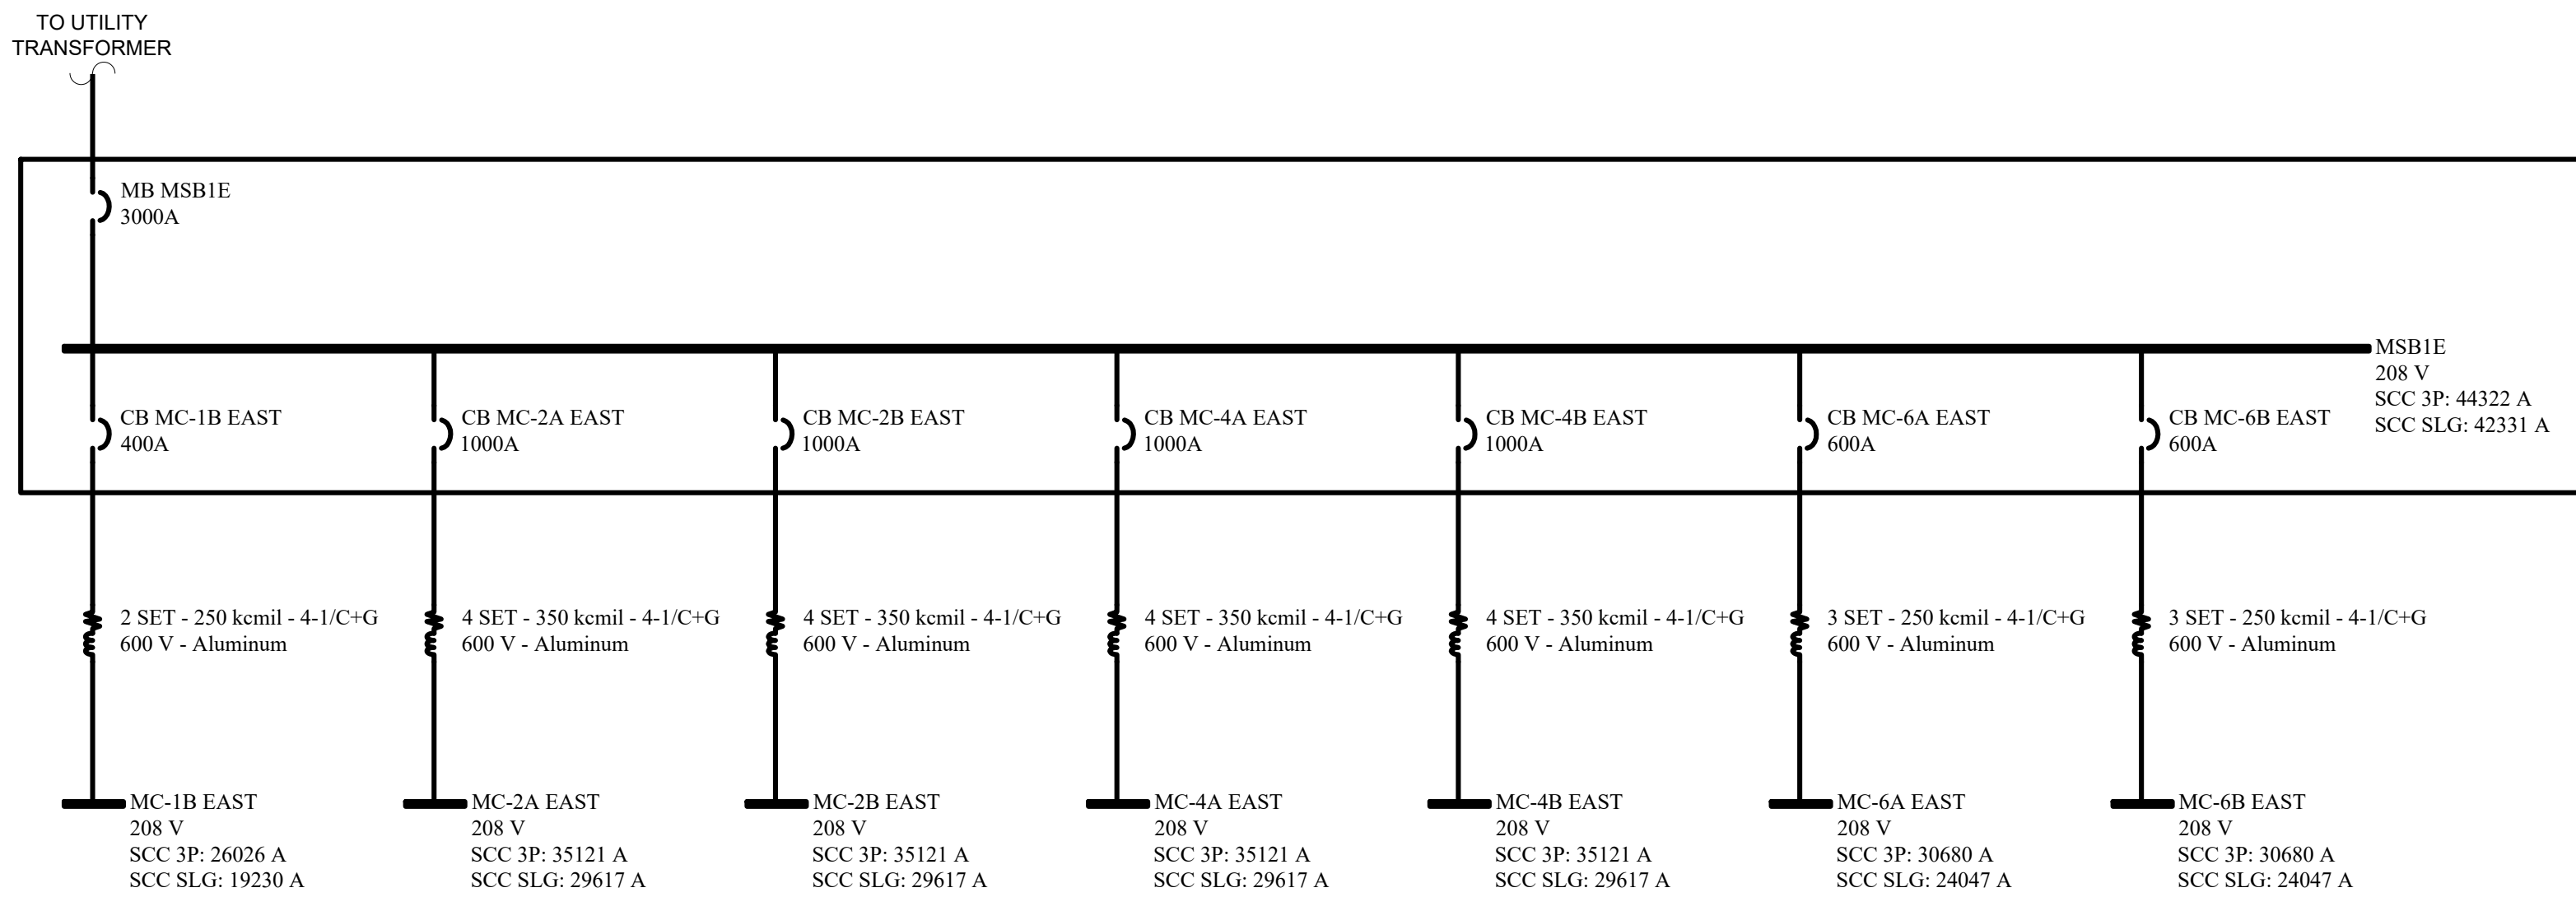

1 ONE-LINE DIAGRAM - EAST BUILDING DOMICILES
E-702 NO SCALE

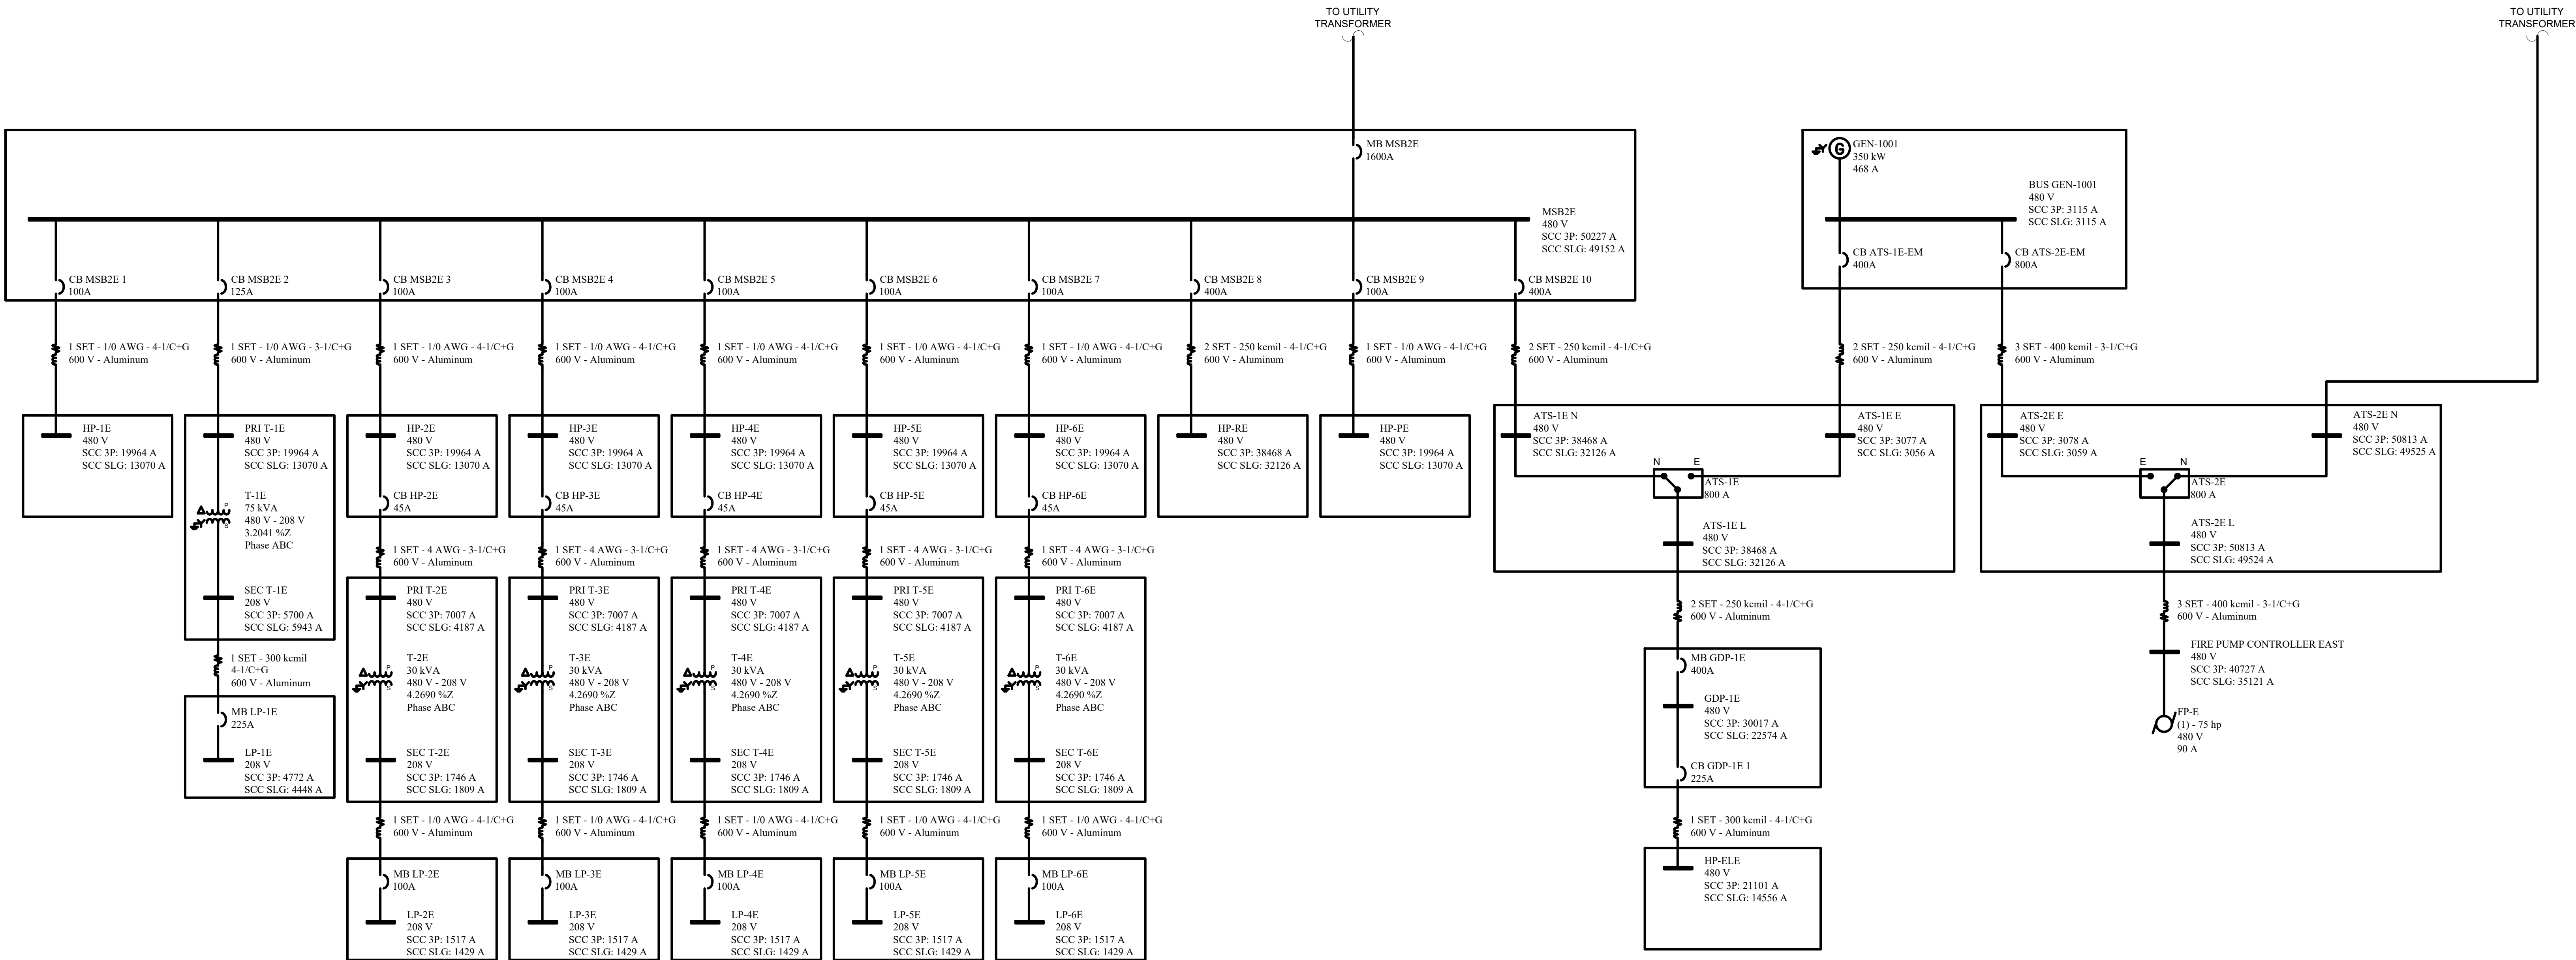

2 ONE-LINE DIAGRAM - EAST BUILDING HOUSE
E-702 NO SCALE

ONE-LINE GENERAL NOTES:

- UNLESS OTHERWISE NOTED, EQUIPMENT SHOWN WITH LIGHT SHADED LINES AND / OR DESIGNATED WITH AN 'X' INDICATES EXISTING AND SHALL REMAIN.
- ALL CABLE LENGTHS ARE ESTIMATED AND SHALL BE USED AS A REFERENCE ONLY. CONTRACTOR SHALL FIELD VERIFY ACTUAL LENGTHS AND RESIZE CONDUCTORS AS REQUIRED TO MEET THE AMPACITY, DE-RATING, AND VOLTAGE DROP REQUIREMENTS OF THE NFPA NATIONAL ELECTRICAL CODE (NEC) AND ENERGY EFFICIENCY CODES. SUBMIT ALL INSTALLED WIRE LENGTHS AND FIELD CHANGES TO THE OWNER AND ENGINEER.
- CONTRACTOR SHALL FIELD VERIFY THE ACTUAL EQUIPMENT NAMEPLATE DATA AND SUBMIT ALL DATA TO THE OWNER AND ENGINEER.
- SHORT CIRCUIT CURRENT (SCC) VALUES ARE BASED ON THE WORST CASE SCENARIO. DATA SHALL NOT BE USED FOR ARC FLASH CALCULATIONS.
- PROVIDE LABELING FOR ALL ELECTRICAL EQUIPMENT INCLUDING EXISTING EQUIPMENT INVOLVED IN PROJECT. SEE LABELING DETAIL SHEETS E002-E004.
- CONTRACTOR SHALL NOT USE SUBSTITUTIONS OR EQUIVALENTS FOR THE PANELBOARDS, CIRCUIT BREAKERS, SURGE PROTECTION DEVICES, OR OTHER EQUIPMENT LISTED ON THIS SHEET.
- NEUTRAL AND GROUNDING CONDUCTORS SHALL BE SEPARATED AND TERMINATED ON THEIR DESIGNATED TERMINATION BAR IN EVERY PANEL.
- CONTRACTOR SHALL TORQUE ALL CONNECTIONS PER THE MANUFACTURER'S REQUIREMENTS. THE ACTUAL FIELD VALUES SHALL BE DOCUMENTED AND PROVIDED TO THE OWNER.
- FIELD VERIFY THE MANUFACTURER, SIZE, AND TYPE OF FUSES / BREAKERS INSTALLED IN ALL EQUIPMENT. PROVIDE THE DATA TO THE OWNER AND ENGINEER.
- BREAKERS ARE SHIPPED WITH FACTORY SETTINGS. OBTAIN BREAKER SETTINGS FROM ENGINEER AND ADJUST ACCORDINGLY.
- ALL WORK SHALL COMPLY WITH GENERAL NOTES ON SHEET E001.
- REFER TO PLANS, SCHEDULES, AND SPECIFICATIONS FOR ADDITIONAL EQUIPMENT INFORMATION.



<https://www.HaysElectrical.com>

THIS PRINT IS THE PROPERTY OF HAYS ELECTRICAL SERVICES. IT MUST NOT BE REPRODUCED IN ANY MANNER NOR SHALL IT BE SUBMITTED TO OUTSIDE PARTIES FOR EXAMINATION WITHOUT OUR CONSENT. IT SHALL BE USED ONLY AS A REFERENCE TO WORK DESIGNED OR FURNISHED BY US.

Project General Notes:
1. Revised layout as needed base on SPEC'S N.E.C. requirement.
2. Installed junction box at accessible location for future service access.
3.
4.

Revision Schedule	Number	Revision Title	Date
	A	100% DESIGN DEVELOPMENT	09/30/2026

100% DESIGN DEVELOPMENT
NOT FOR CONSTRUCTION

RAMBLER BATON ROUGE

BURBANK DR.
BATON ROUGE, LA

Project Number 26078
Date 09/30/2026
Technician C.J.H.
Superintendent WAW
Project Manager SS

ONE-LINE - EAST BLDG

Sheet Number E702