



160 Garland Drive
Suite 900
Marietta, GA 30062
770 255 3971
www.dad-engineering.com

[illegible]

 
RAMBLER BAY L'ON ROUGE

4076 GORRIER AVENUE
BATON ROUGE, LA 70808

LV COLLECTIVE

HEET TITLE:
FAST BLDG. LEVEL 1
PART A - PLUMBING
(B/F)

NOT RELEASED FOR CONSTRUCTION



1. ALL PIPING SHOWN ON THIS SHEET SHALL BE BELOW FLOOR / GRADE UNLESS NOTED OTHERWISE.
2. CONTRACTOR SHALL FULLY COORDINATE THE LOCATION, WIDTH AND DEPTH OF ALL FOOTINGS AND DROP FOOTINGS WITH STRUCTURE AND ALL OTHER TRADES INVOLVED PRIOR TO CONSTRUCTION.
3. REFER TO ARCHITECTURAL DRAWINGS FOR EXACT LOCATIONS OF PARKING DRAINS. PARKING DRAINS SHALL BE 4"ØS. SEE PLUMBING SCHEDULE.



1060 Garland Drive
Suite 900
Bogart, GA 30622
T 706 255 3971
www.dad-engineering.com

[illegible]


RAMBLER BATON ROUGE

4076 GORRIER AVENUE
BATON ROUGE, LA 70808

LY COLLECTIVE

HEET TITLE:
EAST BLDG. LEVEL 1
PART B - PLUMBING
(B/F)


P1.E00E

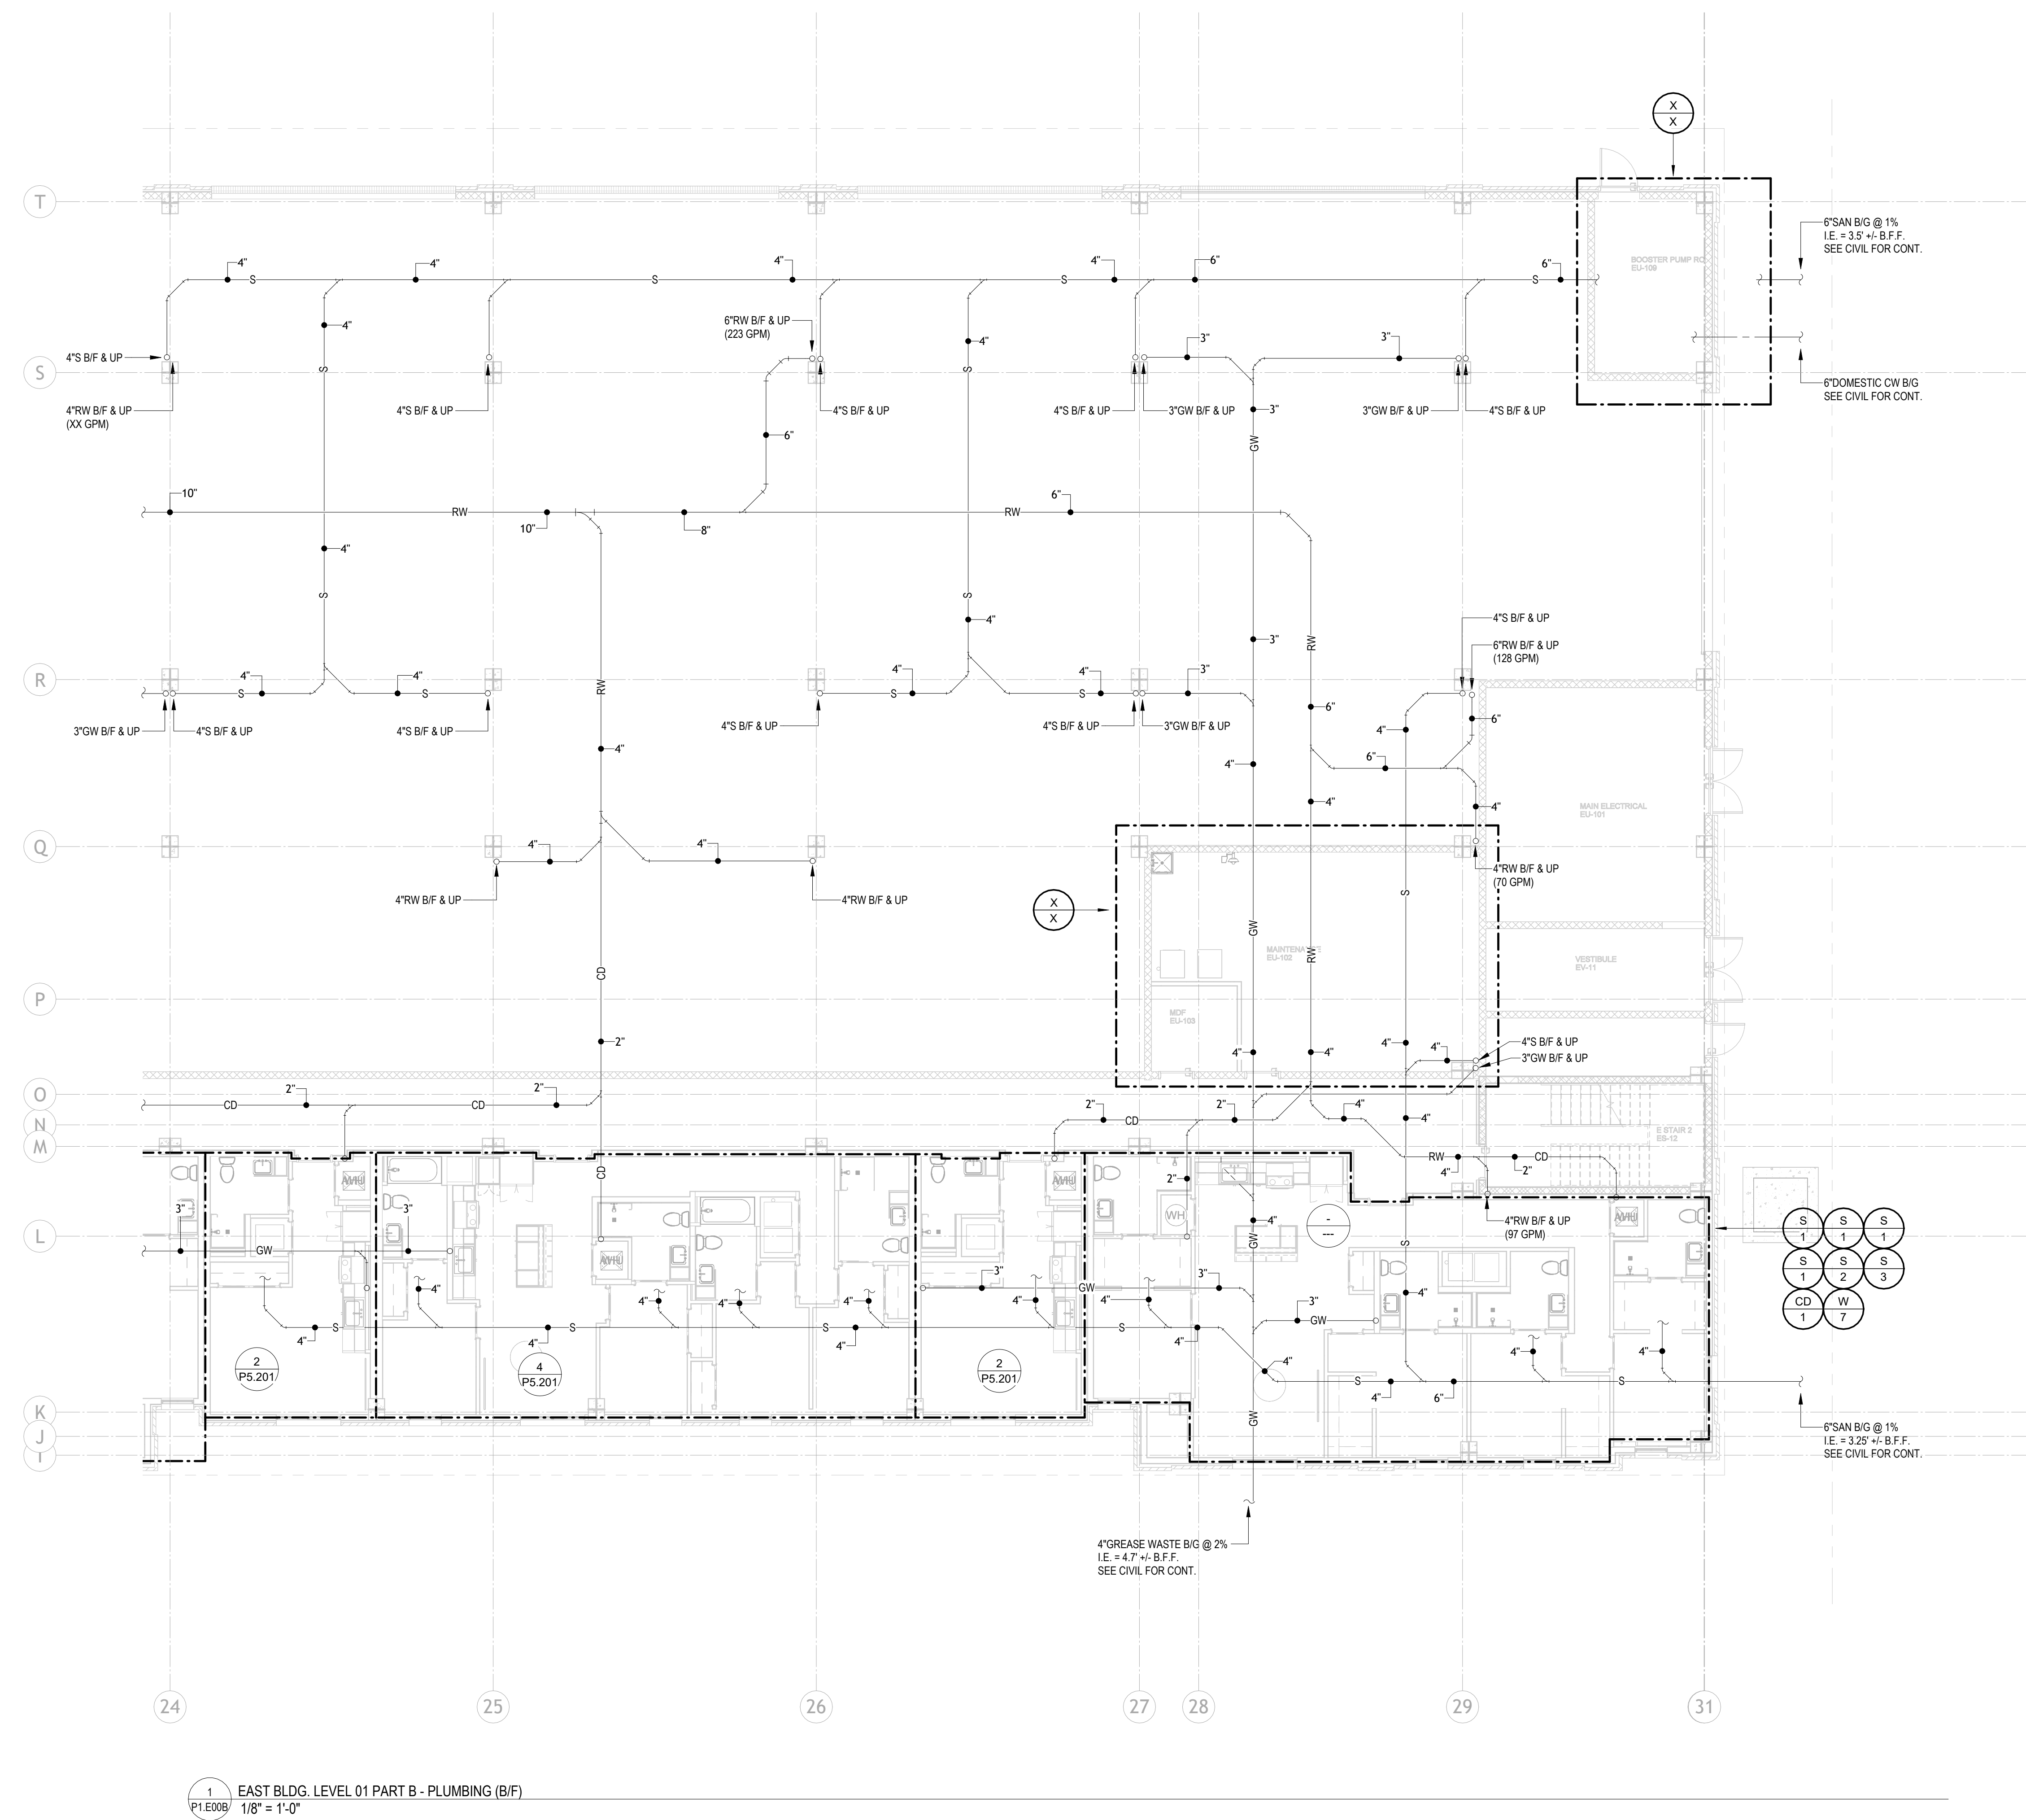

NOTE

1. ALL PIPING SHOWN ON THIS SHEET SHALL BE BELOW FLOOR / GRADE UNLESS NOTED OTHERWISE.
2. CONTRACTOR SHALL FULLY COORDINATE THE LOCATION, WIDTH AND DEPTH OF ALL FOOTINGS AND DROP FOOTINGS WITH STRUCTURE AND ALL OTHER TRADES INVOLVED PRIOR TO CONSTRUCTION.
3. REFER TO ARCHITECTURAL DRAWINGS FOR EXACT LOCATIONS OF PARKING DRAINS. PARKING DRAINS SHALL BE 4"ØS. SEE PLUMBING SCHEDULE.

KEY PLAN

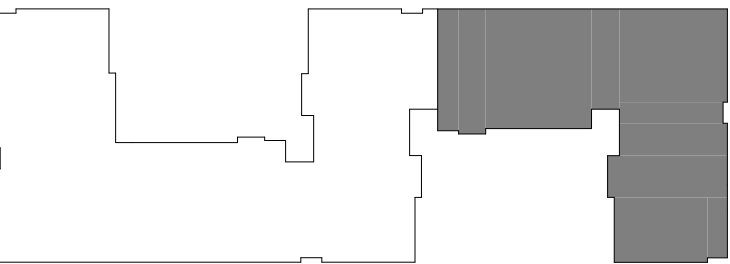



1060 Garland Drive
Suite 900
Bogart, GA 30622
T 706 255 3971
www.dad-engineering.com

[illegible]

 
RAMBLER BATON ROUGE

4076 GORRIER AVENUE
BATON ROUGE, LA 70808

LV COLLECTIVE

HEET NUMBER:
P1.E01A

NOT RELEASED FOR CONSTRUCTION



1. ALL PIPING SHOWN ON THIS SHEET SHALL BE ABOVE FLOOR / GRADE OR OVERHEAD (OH) UNLESS NOTED OTHERWISE.



1060 Garland Drive
Suite 900
Bogart, GA 30622
T 706 255 3971
www.dad-engineering.com

[illegible]


RAMBLER BATON ROUGE

4076 GORRIER AVENUE
BATON ROUGE, LA 70808


LV COLLECTIVE

SHEET TITLE:
EAST BLDG. LEVEL 1
PART B - PLUMBING

HEET NUMBER:
P1.E01B

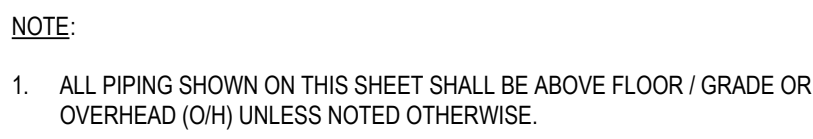

KEY PLAN

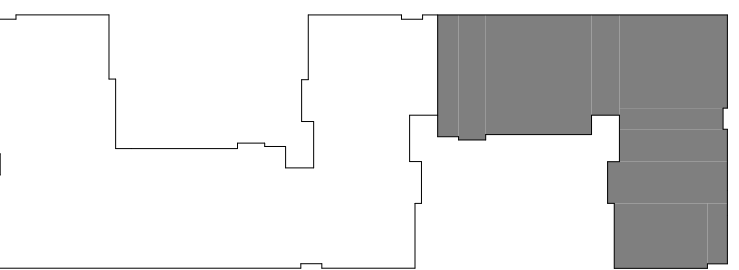



1060 Garland Drive
Suite 900
Bogart, GA 30622
T 706 255 3971
www.dad-engineering.com

[illegible]


RAMBLER BAYON ROUGE

4076 GORRIER AVENUE
BATON ROUGE, LA 70808

LV COLLECTIVE

SHEET TITLE:
EAST BLDG. LEVEL 2
PART A - PLUMBING

HEET NUMBER:
P1.E02A

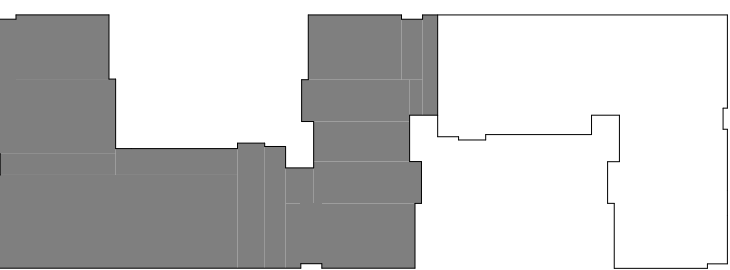



1060 Garland Drive
Suite 900
Bogart, GA 30622
T 706 255 3971
www.dad-engineering.com

[illegible]

RAMBLER BATON ROUGE

4076 GORRIER AVENUE
BATON ROUGE, LA 70808

LV COLLECTIVE


SHEET TITLE:
 EAST BLDG. LEVEL 2
 PART B - PLUMBING

HEET NUMBER:
P1.E02B



1 EAST BLDG. LEVEL 02 PART B - PLUMBING
P1.E02B 1/8" = 1'-0"

KEY PLAN

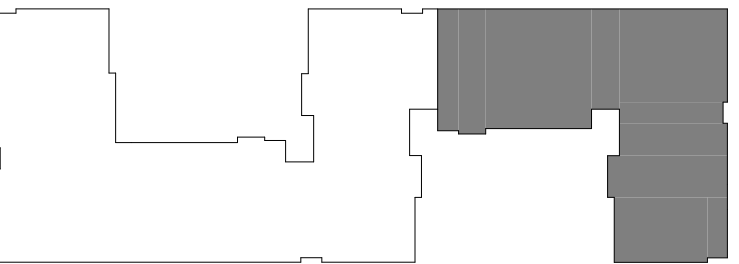



1060 Garland Drive
Suite 900
Bogart, GA 30622
T 706 255 3971
www.dad-engineering.com

[illegible]

RAMBLER BATON ROUGE

4076 GORRIER AVENUE
BATON ROUGE, LA 70808

LV COLLECTIVE

SHEET TITLE:
 EAST BLDG. LEVEL 3
 PART A - PLUMBING

HEET NUMBER:
P1.E03A





1060 Garland Drive
Suite 900
Bogart, GA 30622
T 706 255 3971
www.dad-engineering.com

[illegible]

RAMBLER BATON ROUGE

4076 GORRIER AVENUE
BATON ROUGE, LA 70808

LV COLLECTIVE

HEET TITLE:
EAST BLDG. LEVEL 3
PART B - PLUMBING

P1.E03B





1060 Garland Drive
Suite 900
Bogart, GA 30622
T 706 255 3971
www.dad-engineering.com

[illegible]

RAMBLER BAYON ROUGE

4076 GORRIER AVENUE
BATON ROUGE, LA 70808

LV COLLECTIVE

SHEET TITLE:
EAST BLDG. LEVEL 4
- PART A - PLUMBING

HEET NUMBER:
P1.E04A

NOT RELEASED FOR CONSTRUCTION



1 EAST BLDG. LEVEL 04 PART A - PLUMBING
P1.E04A 1/8" = 1'-0"

KEY PLAN



9/30/2026 1:12:55 PM



1060 Garland Drive
Suite 900
Bogart, GA 30622
T 706 255 3971
www.dad-engineering.com

[illegible]

RAMBLER BATON ROUGE

4076 GORRIER AVENUE
BATON ROUGE, LA 70808

LV COLLECTIVE


HEET TITLE:
EAST BLDG. LEVEL 4
PART B - PLUMBING

HEET NUMBER:
P1.E04B



1 EAST BLDG. LEVEL 04 PART B - PLUMBING
P1.E04B 1/8" = 1'-0"

KEY PLAN

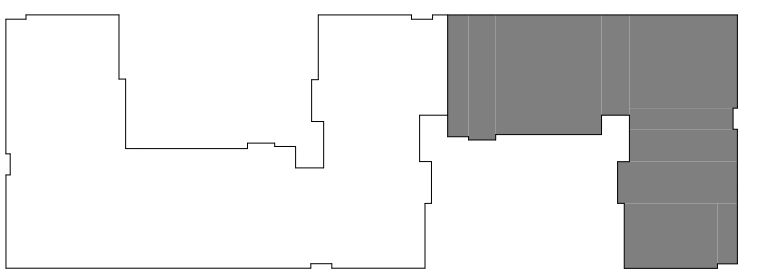



1060 Garland Drive
Suite 900
Bogart, GA 30622
T 706 255 3971
www.dad-engineering.com

[illegible]

RAMBLER BATON ROUGE

4076 GORRIER AVENUE
BATON ROUGE, LA 70808

LV COLLECTIVE

HEET TITLE:
EAST BLDG. LEVEL 5
PART A - PLUMBING

HEET NUMBER:
P1.E05A





1060 Garland Drive
Suite 900
Bogart, GA 30622
T 706 255 3971
www.dad-engineering.com

[illegible]

RAMBLER BATON ROUGE

4076 GORRIER AVENUE
BATON ROUGE, LA 70808

LV COLLECTIVE


HEET TITLE:
EAST BLDG. LEVEL 5
PART B - PLUMBING

P1.E05B



1 EAST BLDG. LEVEL 05 PART B - PLUMBING
P1.E05B 1/8" = 1'-0"

KEY PLAN

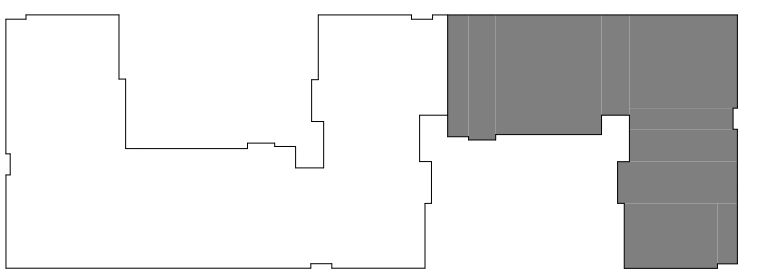



DRAWN BY: Author

CHECKED BY: Checke

www.dad-engineering.com

[illegible]

RAMBLER BATON ROUGE

4076 GORRIER AVENUE
BATON ROUGE, LA 70808

LV COLLECTIVE

DD SET
9/30/2026

SHEET TITLE:
EAST BLDG. LEVEL 6
- PART A - PLUMBING

SHEET NUMBER:

P1.E06A




1 EAST BLDG. LEVEL 06 PART A - PLUMBING
P1.E06A 1/8" = 1'-0"

NOTE

1. ALL STACK VENTS ARE TO BE GANGED TOGETHER TO MINIMIZE ROOF PENETRATIONS. ALL VENT THRU ROOF PENETRATIONS SHALL BE ROUTED TO TERMINATE AT THE LEAST VISIBLE LOCATIONS WHILE MAINTAINING CODE REQUIRED CLEARANCES FROM BUILDING OPENINGS, MECHANICAL EQUIPMENT FRESH AIR INTAKES, ETC.

KEY PLAN

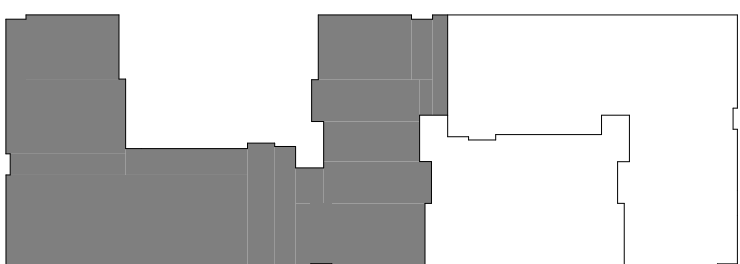

9/30/2026 1:13:51 PM

NOT RELEASED FOR CONSTRUCTION



1060 Garland Drive
Suite 900
Bogart, GA 30622
T 706 255 3971
www.dad-engineering.com

[illegible]

RAMBLER BATON ROUGE

4076 GORRIER AVENUE
BATON ROUGE, LA 70808

LV COLLECTIVE

HEET TITLE:
EAST BLDG. LEVEL 6
PART B - PLUMBING


HEET NUMBER:
P1.E06B



1 EAST BLDG. LEVEL 06 PART B - PLUMBING
P1.E06B 1/8" = 1'-0"

1. ALL STACK VENTS ARE TO BE GANGED TOGETHER TO MINIMIZE ROOF PENETRATIONS. ALL VENT THRU ROOF PENETRATIONS SHALL BE ROUTED TO TERMINATE AT THE LEAST VISIBLE LOCATIONS WHILE MAINTAINING CODE REQUIRED CLEARANCES FROM BUILDING OPENINGS, MECHANICAL EQUIPMENT FRESH AIR INTAKES, ETC.

KEY PLAN

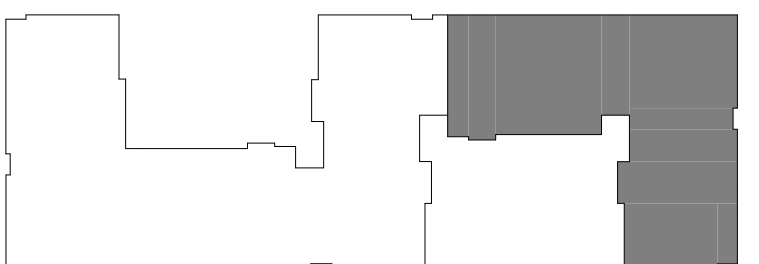



1060 Garland Drive
Suite 900
Bogart, GA 30622
T 706 255 3971
www.dad-engineering.com

[illegible]

RAMBLER BATON ROUGE

4076 GORRIER AVENUE
BATON ROUGE, LA 70808

LV COLLECTIVE

HEET TITLE:
EAST BLDG. ROOF -
PART A - PLUMBING


HEET NUMBER:
P1.ER1A

1 EAST BLDG. ROOF PART A - PLUMBING
P1.ER1A 1/8" = 1'-0"

NOTES:

1. REFER TO ARCHITECTURAL DRAWINGS FOR EXACT LOCATIONS OF ALL ROOF DRAINS.
2. FULLY COORDINATE THE EXACT LOCATIONS OF ALL ROOF HYDRANTS (NERH) WITH MECHANICAL EQUIPMENT AND ALL OTHER TRADES INVOLVED PRIOR TO CONSTRUCTION

KEY PLAN

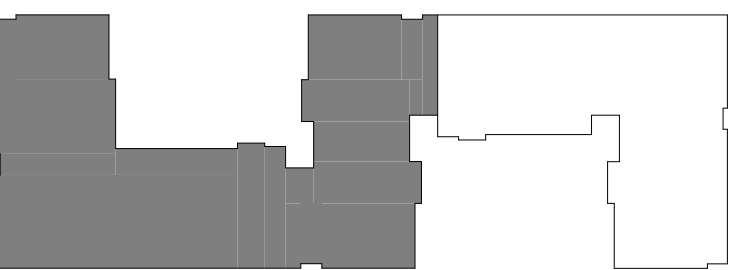



PROJECT # : 26029
DRAWN BY: Author
CHECKED BY: Checker

1060 Garland Drive
Suite 900
Bogart, GA 30622
T 706 255 3971
www.dad-engineering.com

[illegible]

RAMBLER BATON ROUGE

4076 GORRIER AVENUE
BATON ROUGE, LA 70808

LV COLLECTIVE

DD SET
9/30/2026

HEET TITLE:
EAST BLDG. ROOF -
PART B - PLUMBING

HEET NUMBER:


P1.ER1B

1 EAST BLDG. ROOF PART B - PLUMBING
P1.ER1B 1/8" = 1'-0"

NOTES:

1. REFER TO ARCHITECTURAL DRAWINGS FOR EXACT LOCATIONS OF ALL ROOF DRAINS.
2. FULLY COORDINATE THE EXACT LOCATIONS OF ALL ROOF HYDRANTS (NEBH) WITH MECHANICAL EQUIPMENT AND ALL OTHER TRADES INVOLVED PRIOR TO CONSTRUCTION.

KEY PLAN

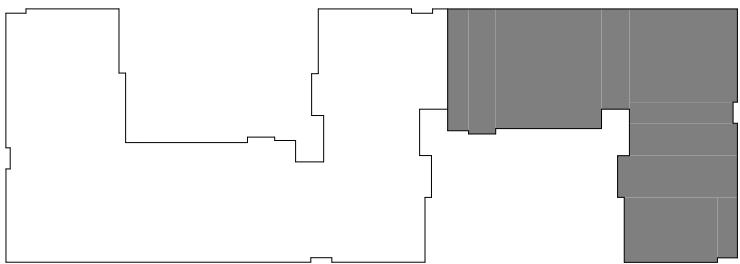



A D | ENGINEERING

PROJECT # : 26029
DRAWN BY: Author
CHECKED BY: Checker

1060 Garland Drive
Suite 900
Bogart, GA 30622
T 706 255 3971
www.dad-engineering.com

[illegible]

RAMBLER BATON ROUGE


4076 GORRIER AVENUE
BATON ROUGE, LA 70808

LV COLLECTIVE

DD SET
9/30/2026

SHEET TITLE:
EAST BLDG.
ENLARGED PARTIAL
PLANS - PLUMBING

SHEET NUMBER:
P2.001

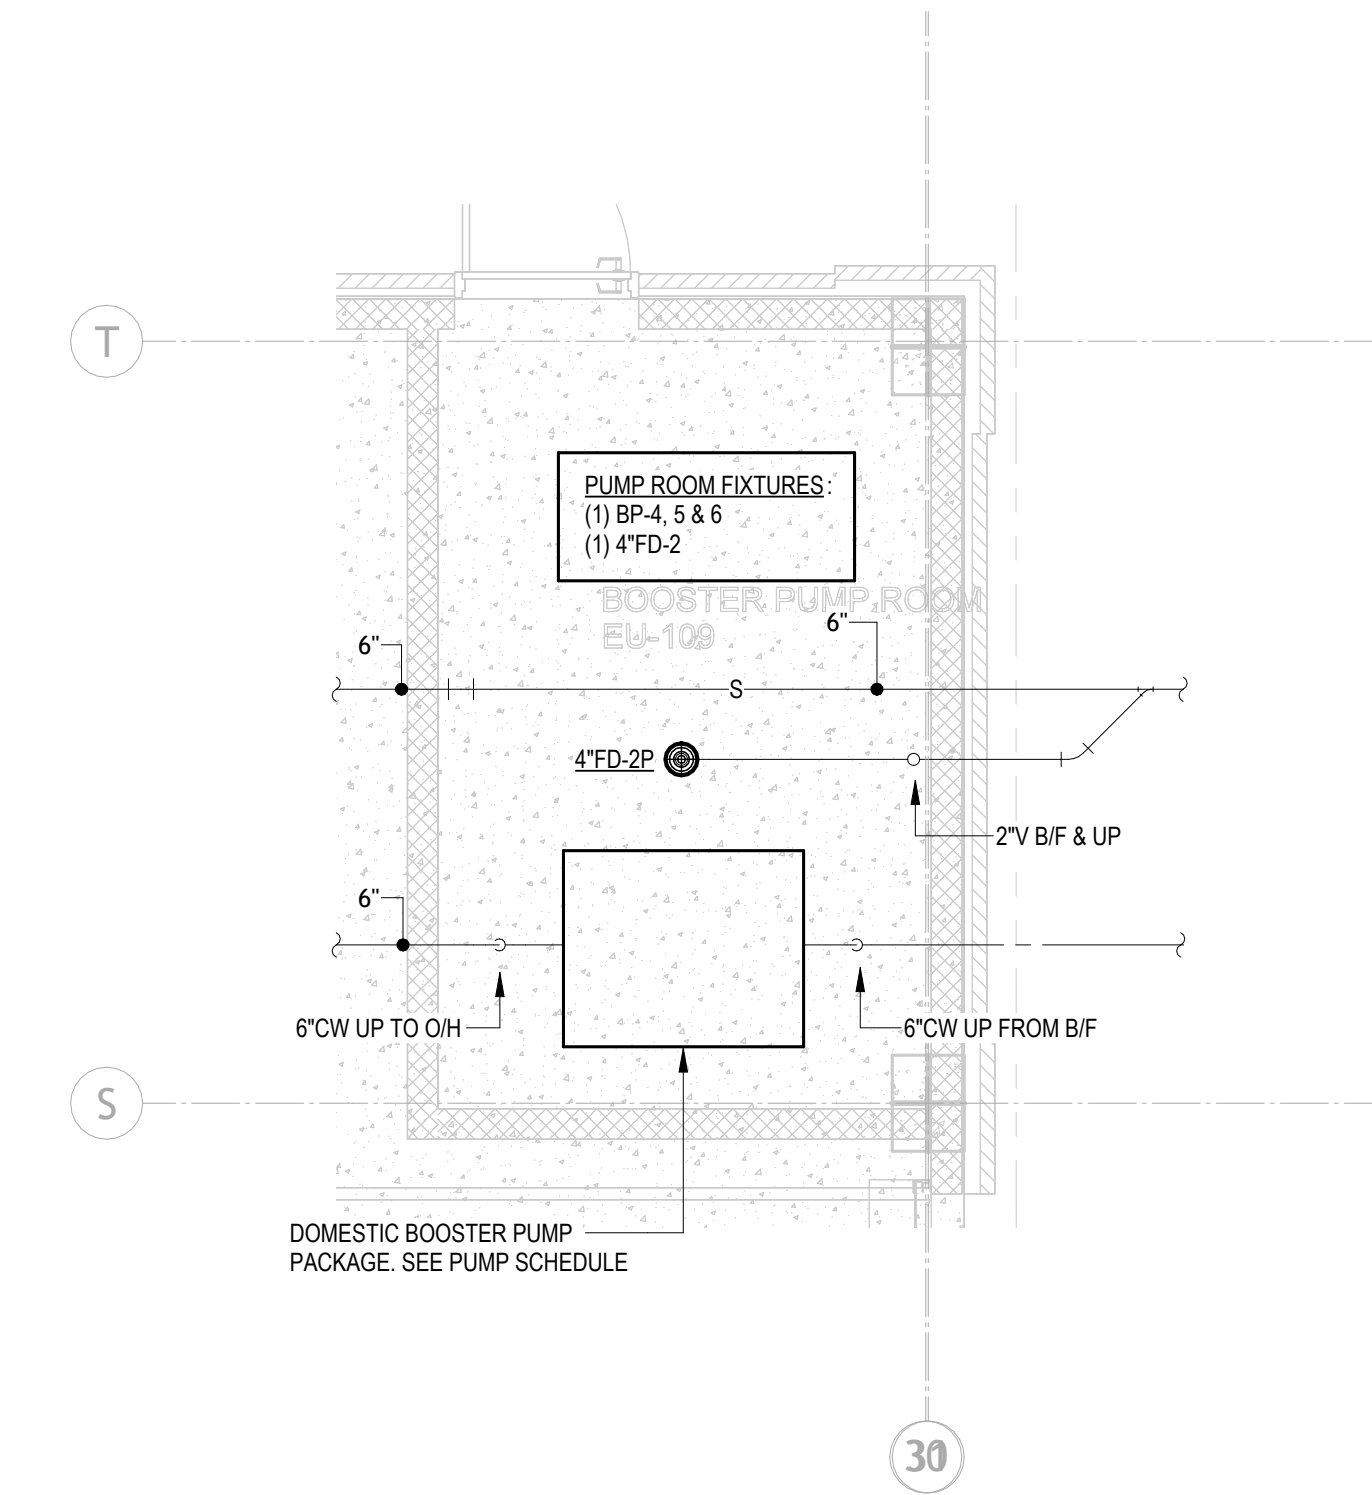

3 ENLARGED PLAN - EAST BLDG. PUMP ROOM - PLUMBING
P2.001 1/4" = 1'-0"

1 ENLARGED PLAN - EAST BLDG. MAINTENANCE ROOM - PLUMBING
P2.001 1/4" = 1'-0"



1060 Garland Drive
Suite 900
Bogart, GA 30622
T 706 255 3971
www.dad-engineering.com

RAMBLER BATON ROUGE

4076 GORRIER AVENUE
BATON ROUGE, LA 70808

LV COLLECTIVE

SHEET TITLE:
SHARED UNIT PLANS

HEET NUMBER:

P5.201

- [illegible]

[illegible]

UNIT D1
WE 255

WATER W

KS-1

WC-1

BT-1

SH-1

WMB

LAV-1

WH-2

HD-1

CD

IM-1

BT-1

WC-1

3" SANITARY S

2" YWSV

2" SANITARY

3" SANITARY S

3" SANITARY

KEY PLAN

LEVEL 1

LEVEL 2

LEVEL 3-6



1060 Garland Drive
Suite 900
Bogart, GA 30622
T 706 255 3971
www.dad-engineering.com

RAMBLER BATON ROUGE

4076 GORRIER AVENUE
BATON ROUGE, LA 70808

LV COLLECTIVE

SHEET TITLE:
PLUMBING RISE
DIAGRAMS

NOT RELEASED FOR CONSTRUCTION

9/30/2026 1:14:27 PM



1060 Garland Drive
Suite 900
Bogart, GA 30622
T 706 255 3971
www.dad-engineering.com

RAMBLER BATON ROUGE

 


4076 GORRIER AVENUE
BATON ROUGE, LA 70808

LV COLLECTIVE

SHEET NUMBER:
P6.002

NOTE:

1. RISER DIAGRAMS, BOTH SANITARY AND DOMESTIC WATER, ARE DIAGRAMMATIC. VERTICAL COMPONENTS OF RISERS MAY OFFSET. CONTRACTOR SHALL COORDINATE ALL OFFSETTING WITH FLOOR PLANS AND ALL OTHER TRADES INVOLVED PRIOR TO CONSTRUCTION. CONTRACTOR SHALL ADD RELIEF VENT PIPING WHERE REQUIRED BY CODE.

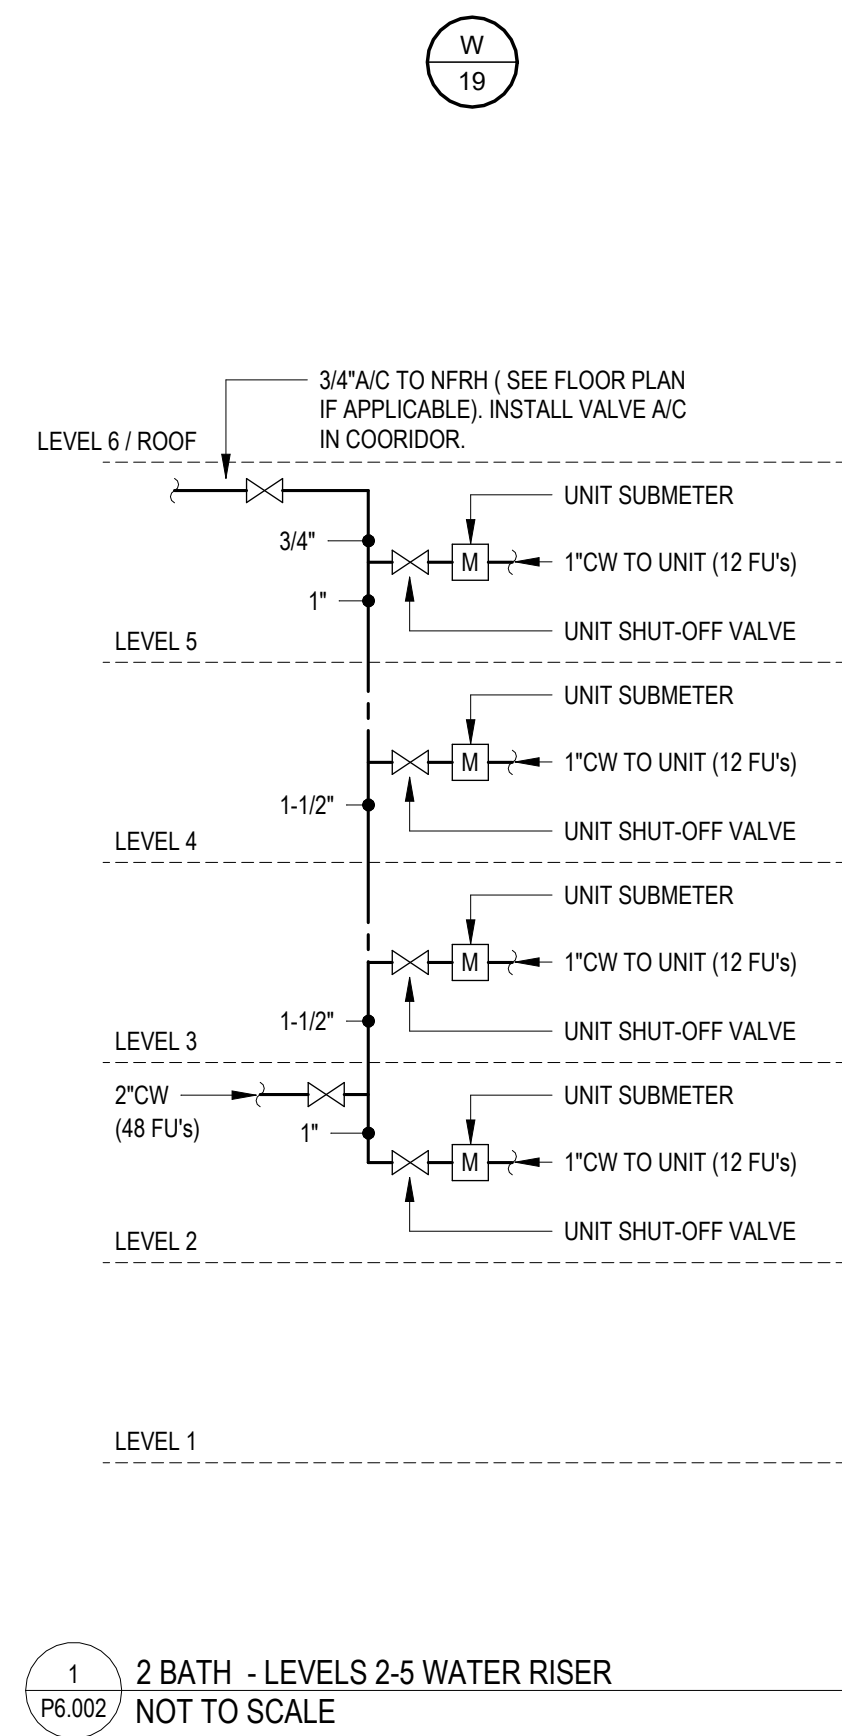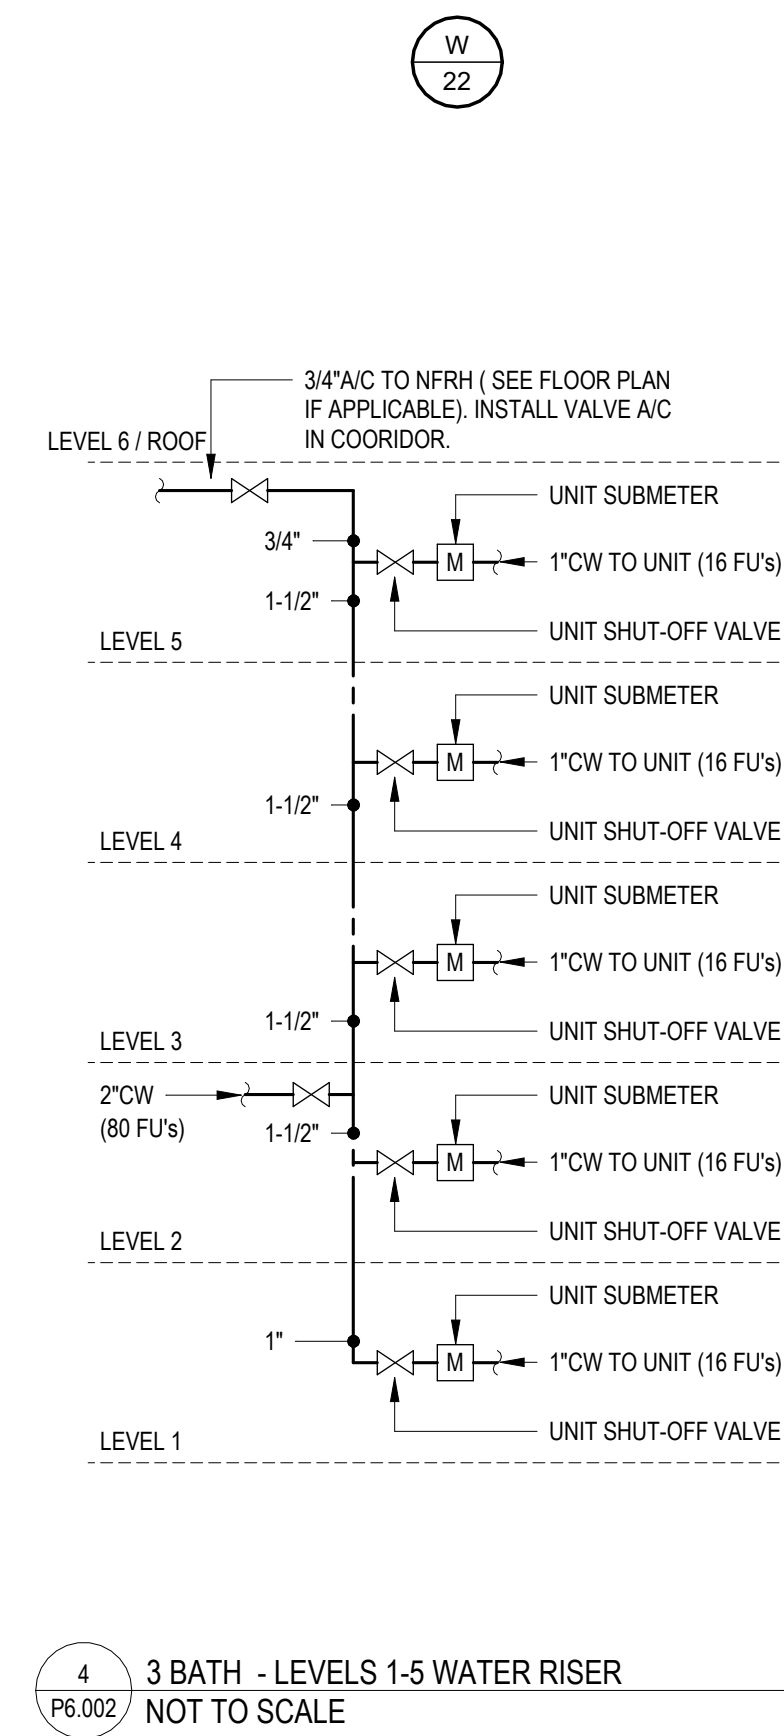



DRAWN BY: Author

www.dad-engineering.com

[illegible]

RAMBLER BATON ROUGE

4076 GORRIER AVENUE
BATON ROUGE, LA 70808

LV COLLECTIVE

DD SET
9/30/2026

SHEET TITLE:
**PLUMBING RISER
DIAGRAMS**


SHEET NUMBER:

P6.003


NOT RELEASED FOR CONSTRUCTION

NOTE


1. RISER DIAGRAMS, BOTH SANITARY AND DOMESTIC WATER, ARE DIAGRAMMATIC. VERTICAL COMPONENTS OF RISERS MAY OFFSET. CONTRACTOR SHALL COORDINATE ALL OFFSETTING WITH FLOOR PLANS AND ALL OTHER TRADES INVOLVED PRIOR TO CONSTRUCTION. CONTRACTOR SHALL ADD RELIEF VENT PIPING WHERE REQUIRED BY CODE.

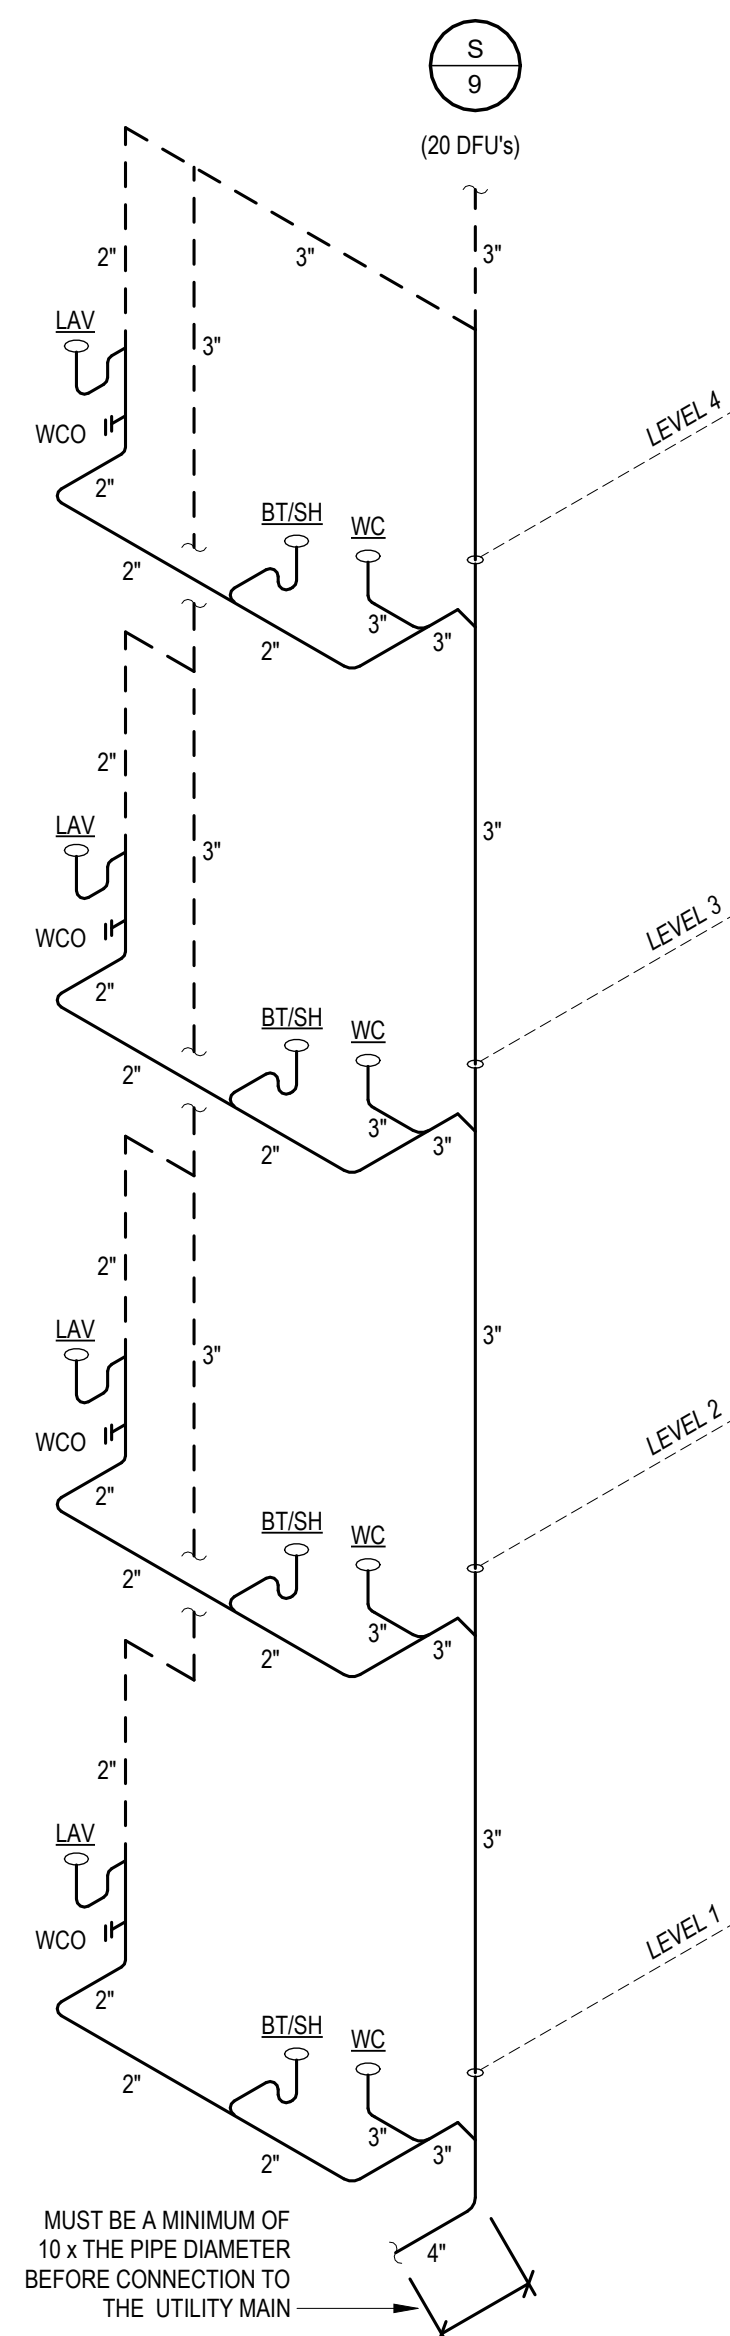


2 TYPICAL SANITARY RISERS - 4 LEVELS
P6.003 NOT TO SCALE

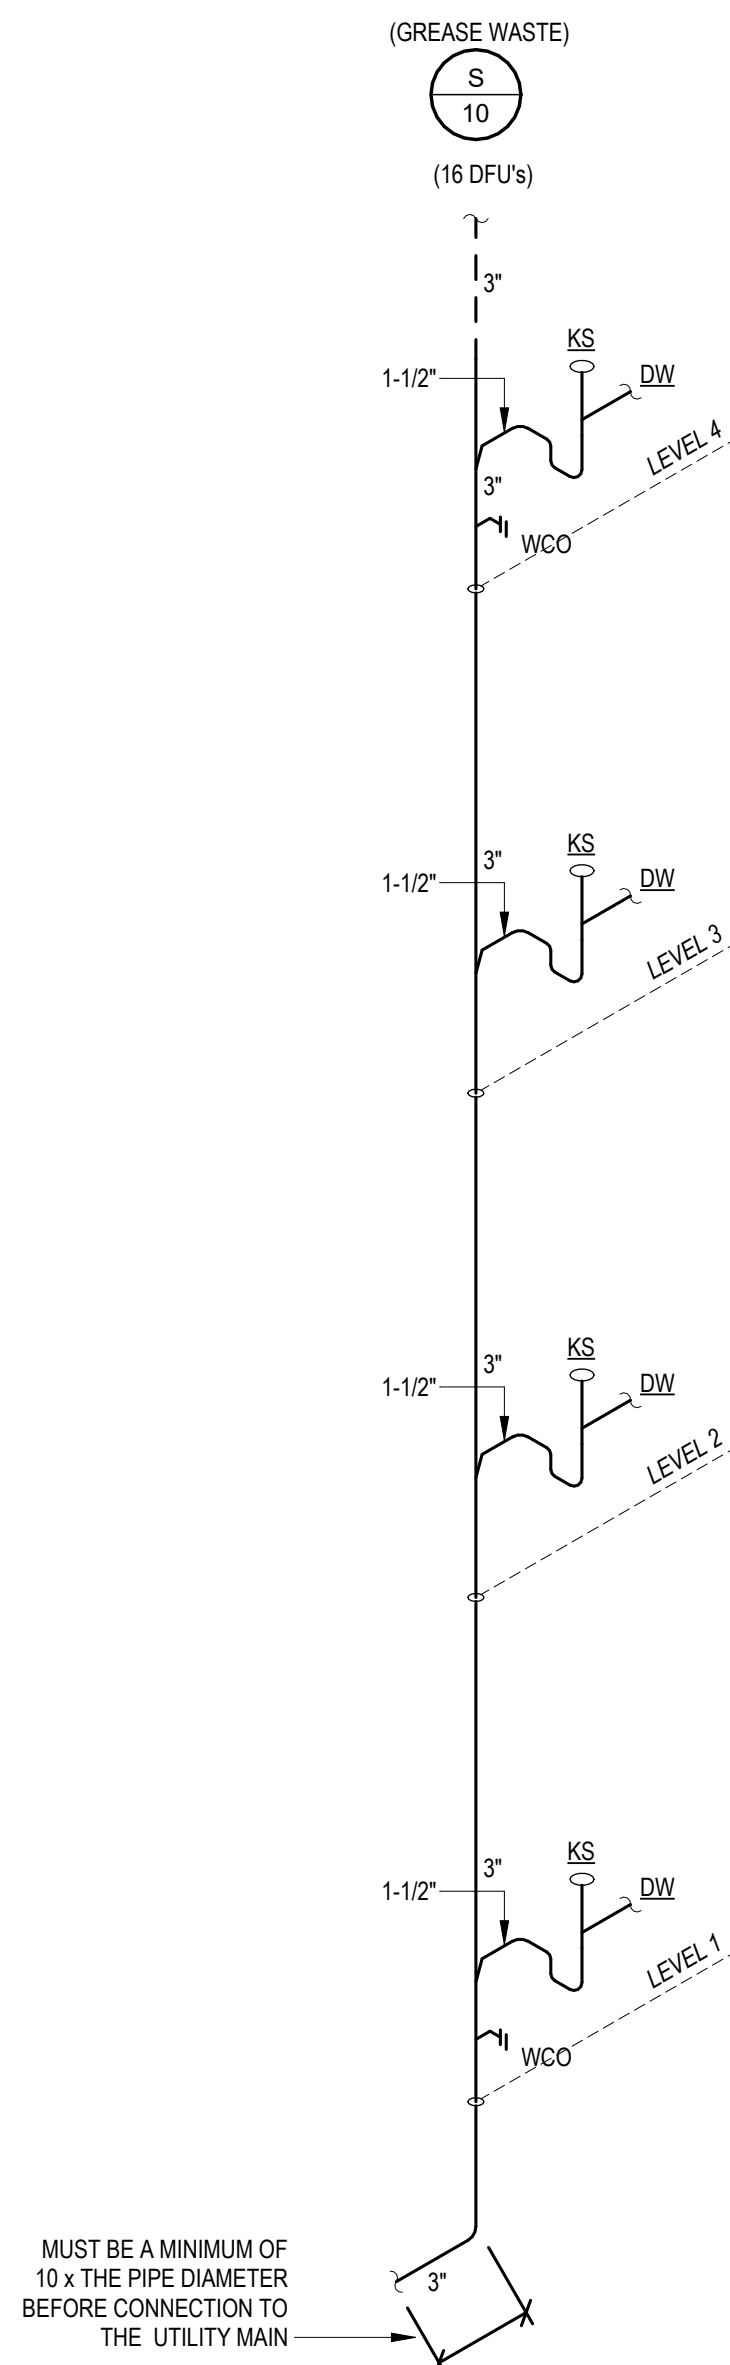

1 TYPICAL SANITARY RISERS - 5 LEVELS
P6.003 NOT TO SCALE

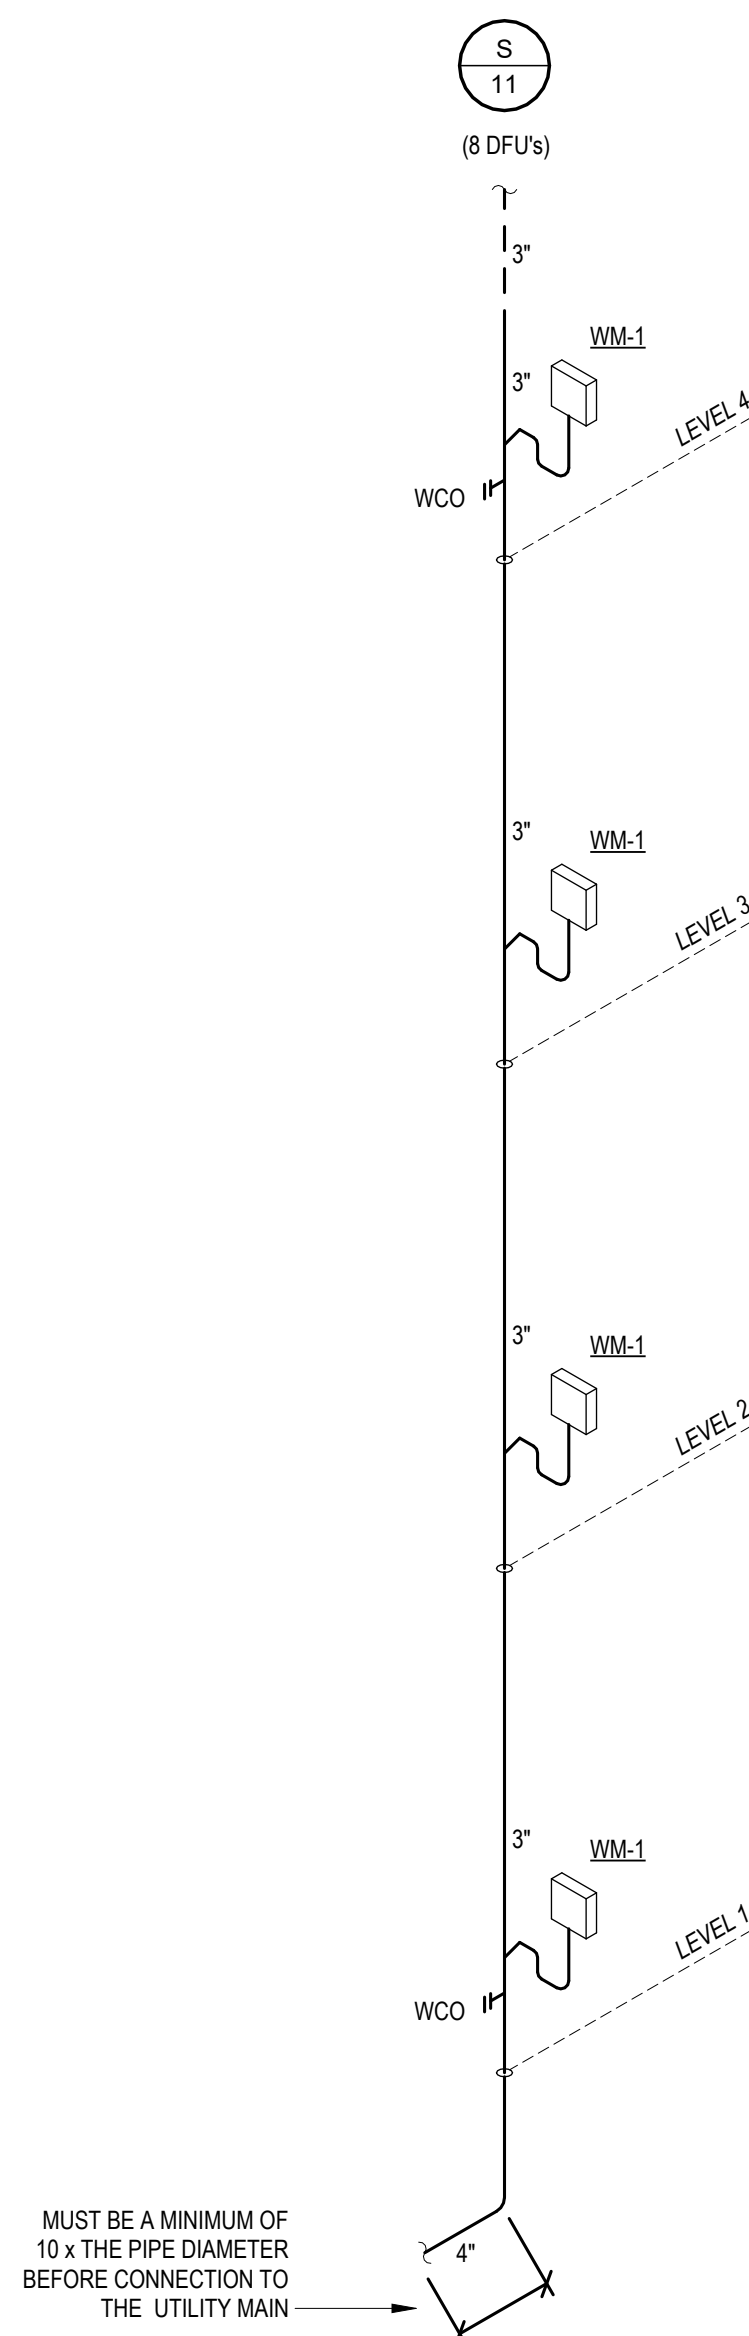

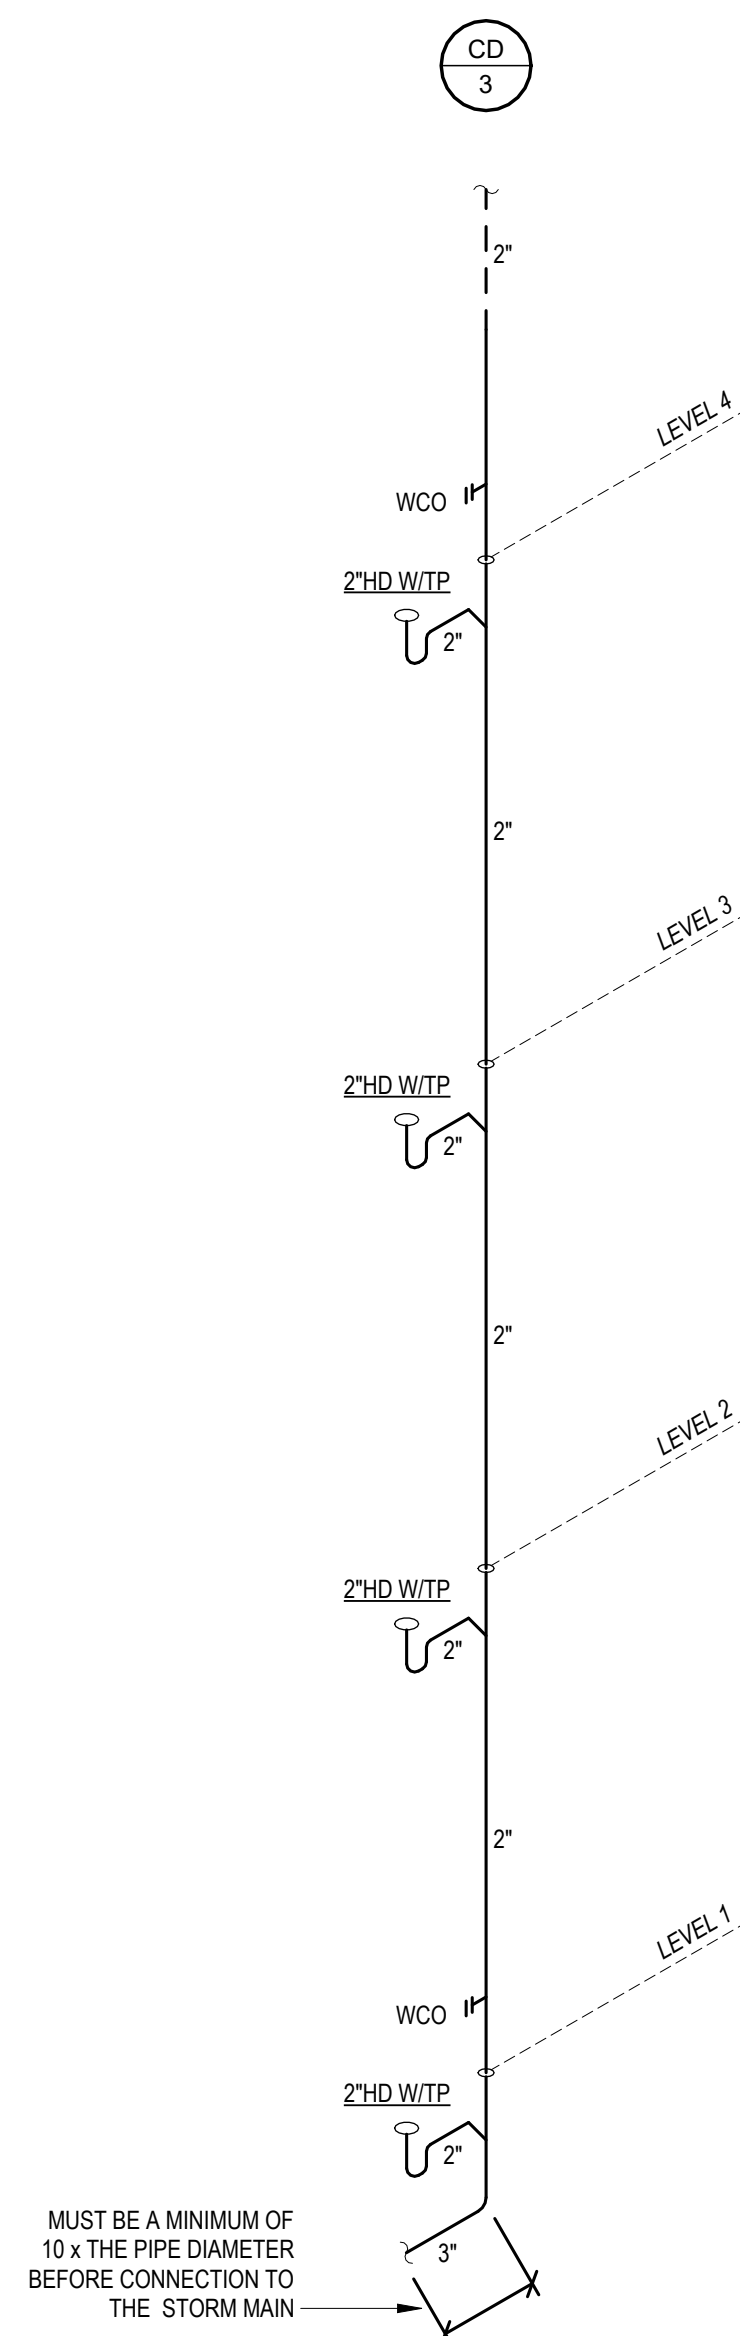

9/30/2026 1:14:29 PM

RAMBLER BATON ROUGE

4076 GORRRIER AVENUE
BATON ROUGE, LA 70808

LV COLLECTIVE

P7.001



Diagram illustrating the components and dimensions of a wall access cover and frame assembly:

- SANITARY / RAINWATER PIPE
- HUB
- CLEANOUT PLUG
- WALL ACCESS COVER AND FRAME
- SPIGOT
- WALL
- FLOOR
- LONG SWEPT ELL AND 45° CO OCCURS AT END OF
- SEAL
- 30"
- FLOW



 
 
 
 
 
 
 
 


Diagram illustrating the components and connections for a trap seal primer system:

  - DOMESTIC WATER LINE
- TRAP PRIMER VALVE
- 3/8" TRAP PRIMER LINE TO FLOOR DRAIN
- PVC SLEEVE
- TRAP SEAL PRIMER CONNECTOR
- BRAINCH WATER LINE
- DOMESTIC WATER LINE
- TRAP PRIMER
- TRAP SEAL PRIMER DISTRIBUTION UNIT
- FLOOR DRAIN
- FLOOR SLAB





PROJECT # : 26029

DRAWN BY: Author

CHECKED BY: Checker

1060 Garland Drive

Suite 900

Dugan C, UK 50022

T 706 255 3971

www.dad-engineering.com

[illegible]

RAMBLER BATON ROUGE

4076 GORRIER AVENUE
BATON ROUGE, LA 70808

LV COLLECTIVE

 
 
 
 
 
DD SET
9/30/2026

SHEET TITLE:
EAST UNIT PLANS


SHEET NUMBER

P5.200


9/30/2026 1:14:41 PM




KEY PLAN

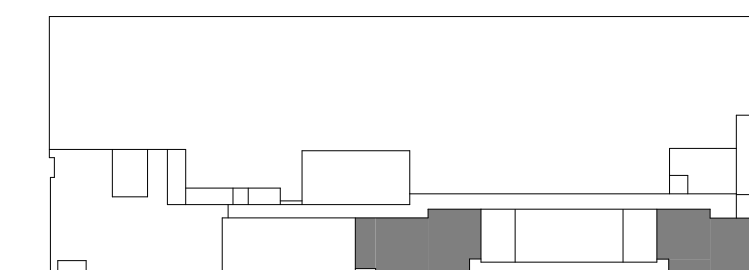

LEVEL 1

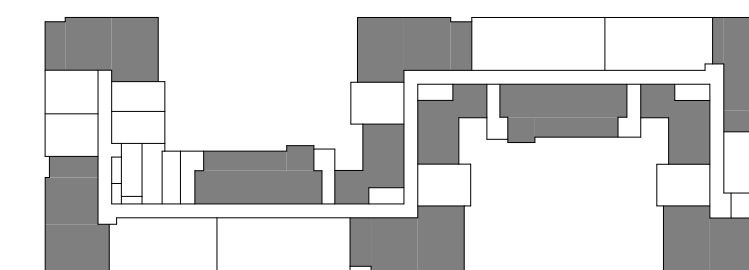

LEVEL 2

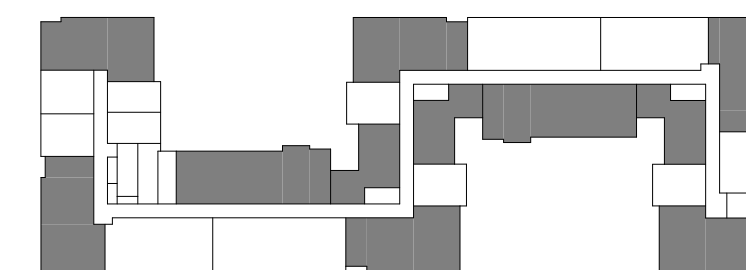

LEVEL 3-6

[illegible]