

# AFTA GROUNDS LIGHTING

# SAU TECH

# CAMDEN, ARKANSAS

## PROJECT INFORMATION

DRAWINGS AND PROJECT MANUAL APPROVED AND IDENTIFIED AS PARTS OF THE OFFICIAL CONTRACT DOCUMENT

OWNER: SAU TECH  
FACILITY: AFTA GROUNDS LIGHTING  
LOCATION: CAMDEN, ARKANSAS

BY: \_\_\_\_\_  
DATE: \_\_\_\_\_


ARCHITECT: LEWIS, ELLIOTT, McMORRAN, VADEN,  
RAGSDALE, & WOODWARD INCORPORATED  
ADDRESS: 11225 HURON LANE, SUITE 104  
LITTLE ROCK, ARKANSAS 72211

BY: \_\_\_\_\_  
DATE: \_\_\_\_\_

PROJECT NUMBER: 24094  
DRAWINGS AND PROJECT MANUAL DATED: 2025 12-05

## VICINITY MAP

14668 HIGHWAY 203, CAMDEN AR 7170

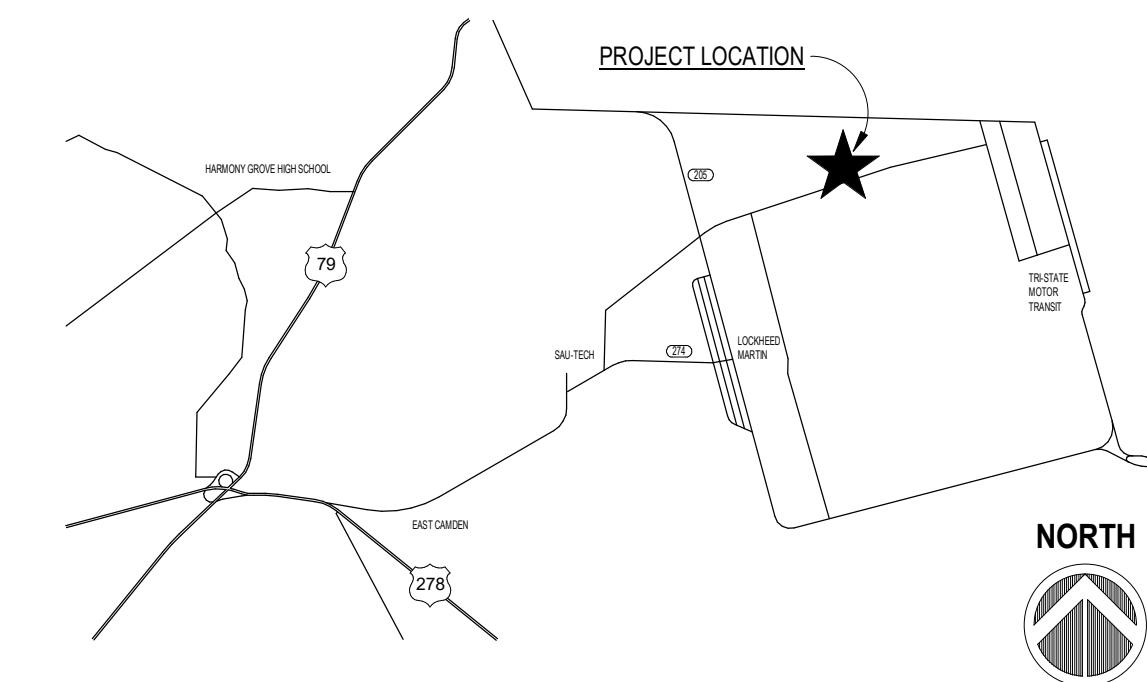

## INDEX OF DRAWINGS

## T1.1 TITLE SHEET

## CIVIL

## ELECTRICAL


## E1.0 SITE PLAN

LEWIS  
ARCHITECTS  
ENGINEERS  
**lc**  
ELLIOTT • McMORRAN • VADEN  
RAGSDALE • WOODWARD • INCORPORATED  
501 223 9302 • [WWW.LEMVRW.COM](http://WWW.LEMVRW.COM)

# AFTA GROUNDS LIGHTING

## SAU TECH

## CAMDEN ARKANSAS

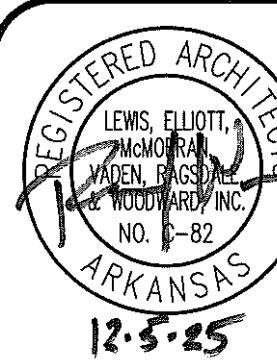


DATE: 2025 12  
PROJECT NO: 240  
DRAWN BY:  
REV:

## T1.1

MARK	DESCRIPTION	MANUFACTURER	MODEL	WATTAGE	VOLTAGE	NOTES
SA	SITE LIGHT SINGLE HEAD	Current	VP-MIRCOSTRIKE-3-480L-285-4K7-4W-UNV-A-FINISH	285	UNV	PROVIDE CONFIGURATION AS SHOWN ON PLANS. UTILIZE POLE TYPE: SSS306G (DMXXAS) FINISH
SB	SITE LIGHT (2) HEADS @ 90	Current	VP-MIRCOSTRIKE-3-480L-285-4K7-4W-UNV-A-FINISH	285	UNV	PROVIDE CONFIGURATION AS SHOWN ON PLANS. UTILIZE POLE TYPE: SSS306G (DMXXAS) FINISH
SC	FLOOD LIGHT W/ KNUCKLE	Current	VP-MIRCOSTRIKE-3-480L-390-4K7-4W-UNV-K-FINISH	390	UNV	PROVIDE CONFIGURATION AS SHOWN ON PLANS. UTILIZE POLE TYPE: SSS306G (DMXXAS) FINISH


COMMENTS:

1. ALL HEIGHTS ARE IN REGARDS TO THE CENTERLINE OF FIXTURE - UNO.
2. CONTRACTOR SHALL PROVIDE/SUBMIT COMPATIBLE LOW-VOLTAGE DIMMER SWITCHES WITH THE FINAL SELECTED FIXTURE SUBMITTALS.

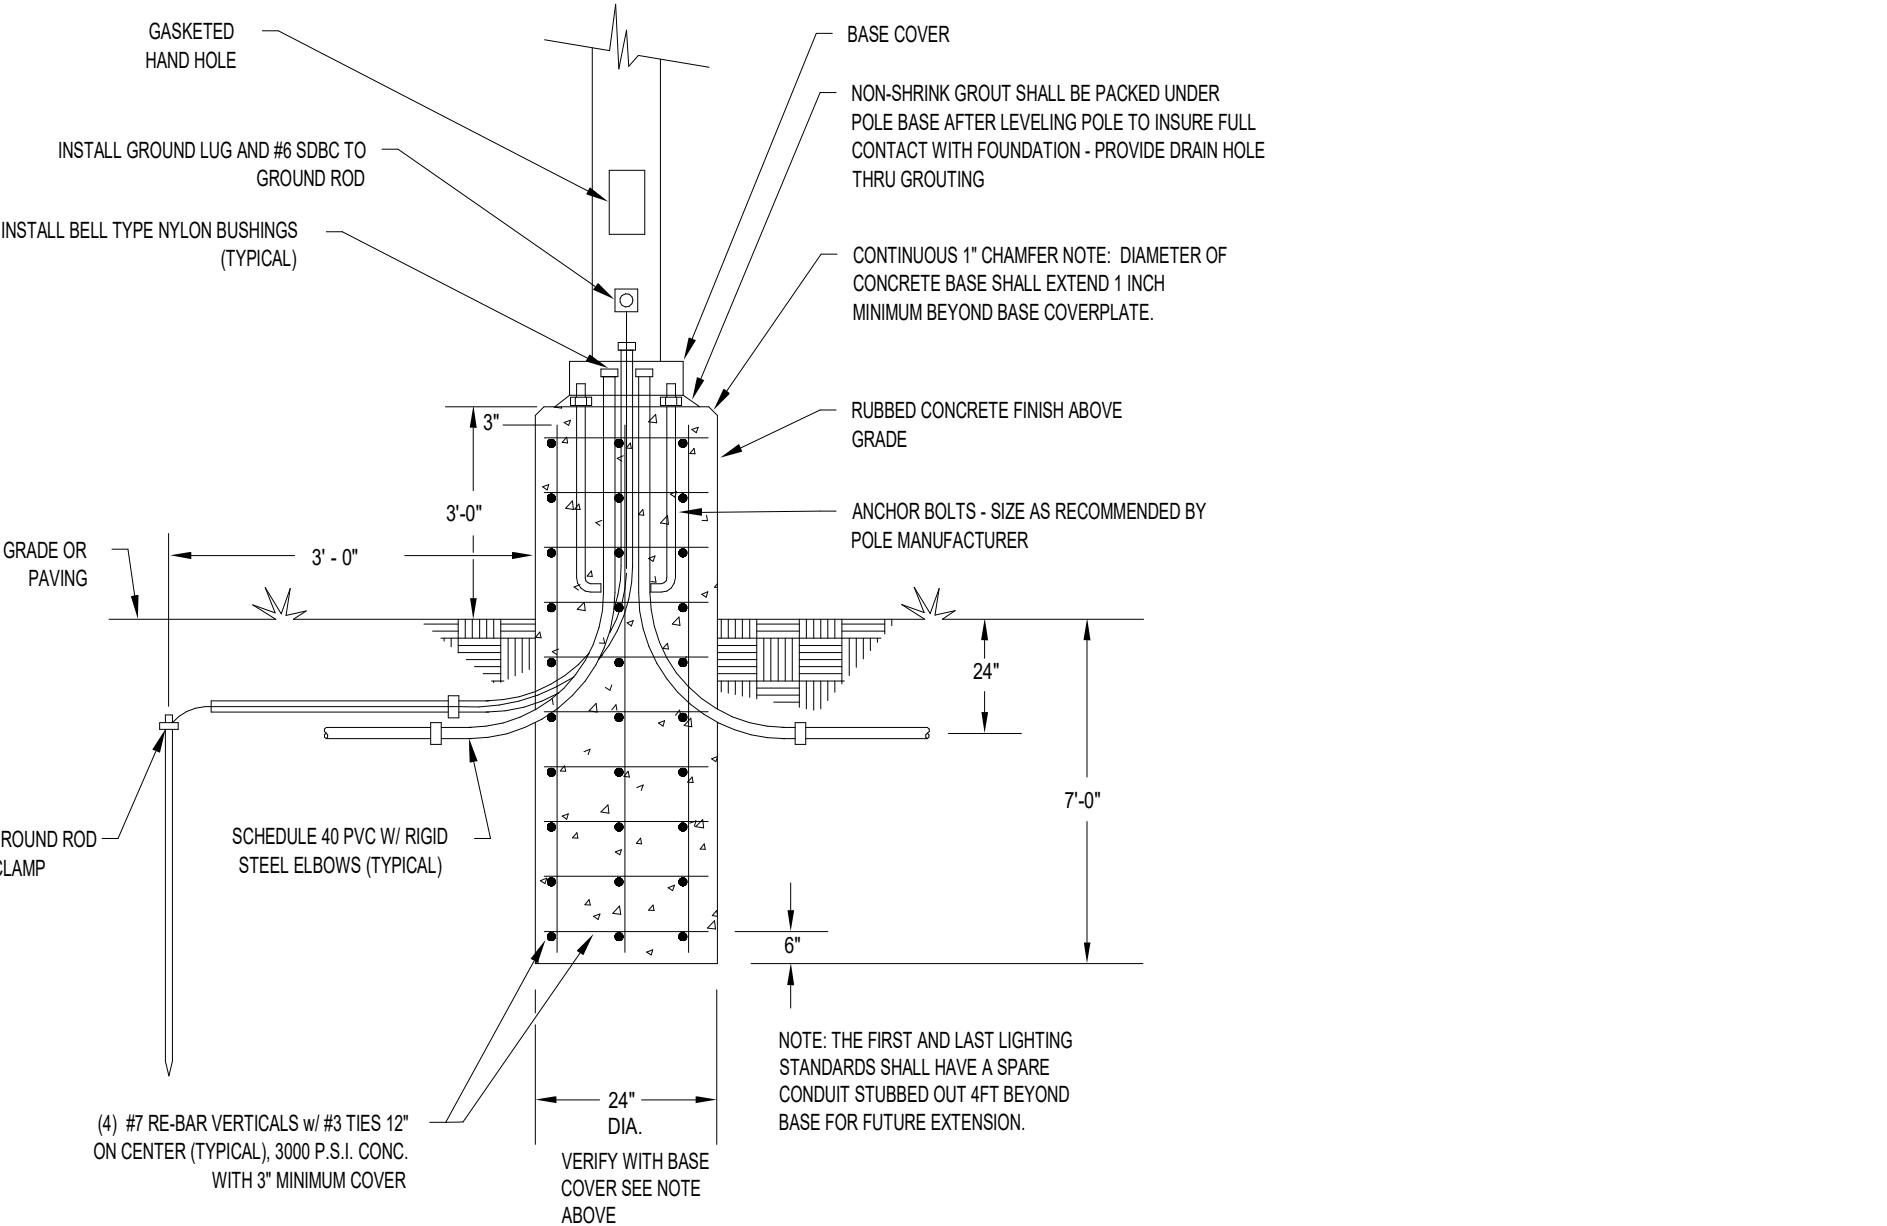


LIGHT POLE BASE DET

E1.0  
NOT TO SCALE

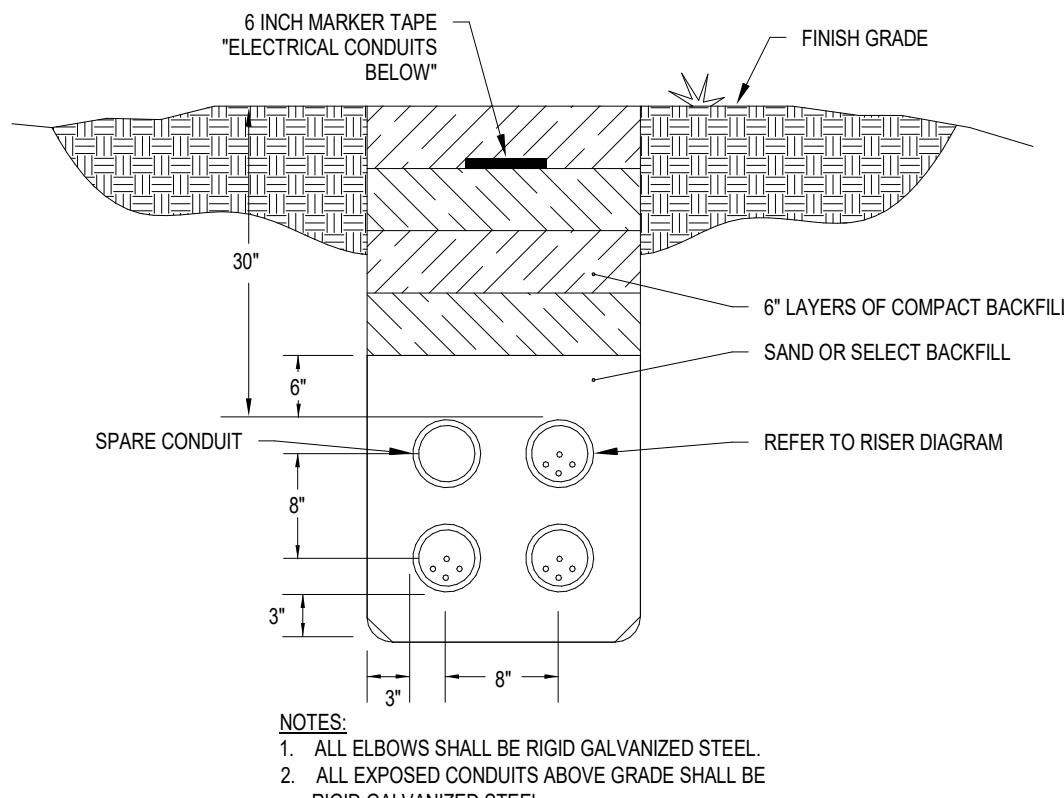


POWER TRENCH DETAIL SITE

E1.0  
NOT TO SCALE

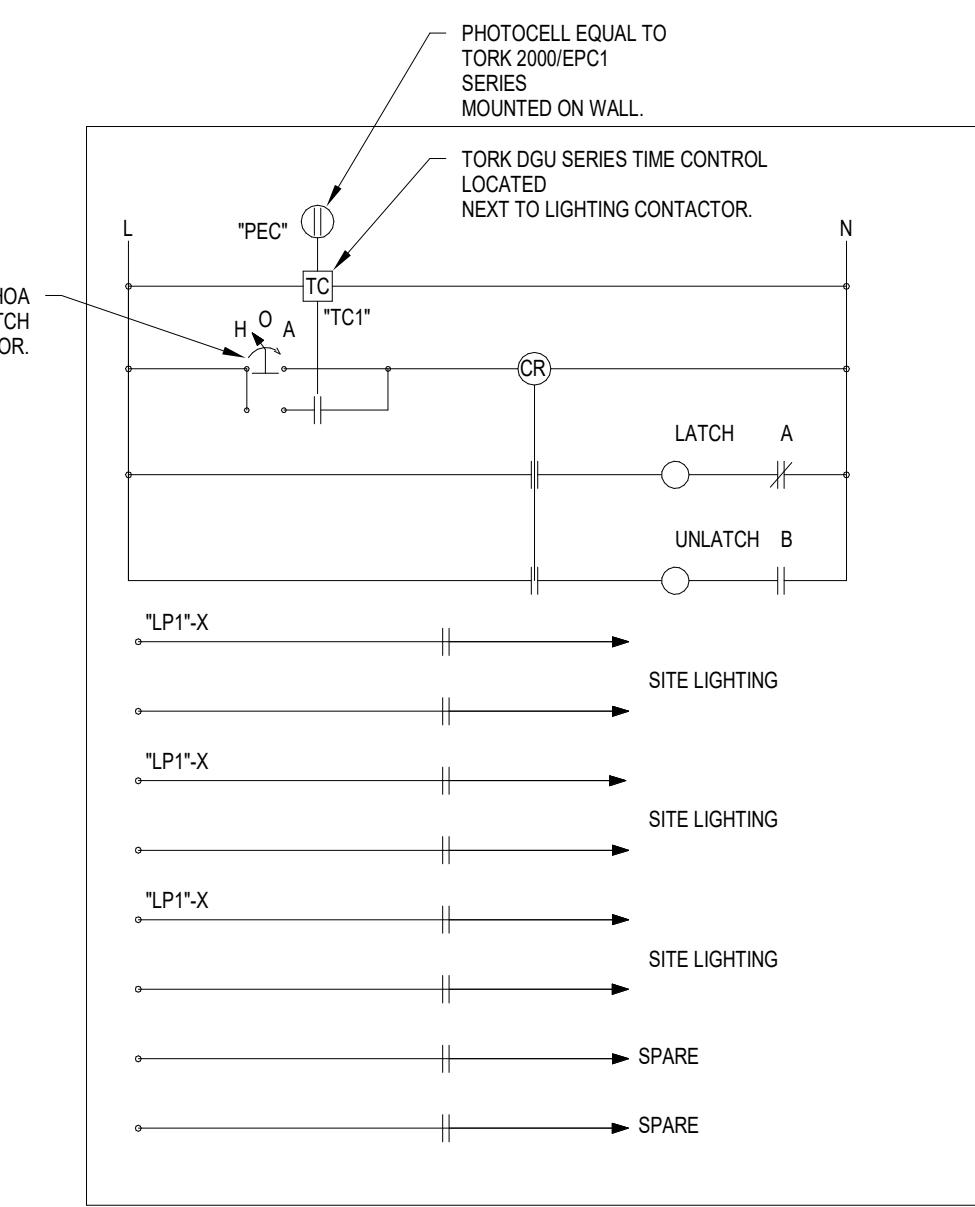

LIGHTING CONTACTOR - LC2

E1.0  
NOT TO SCALE

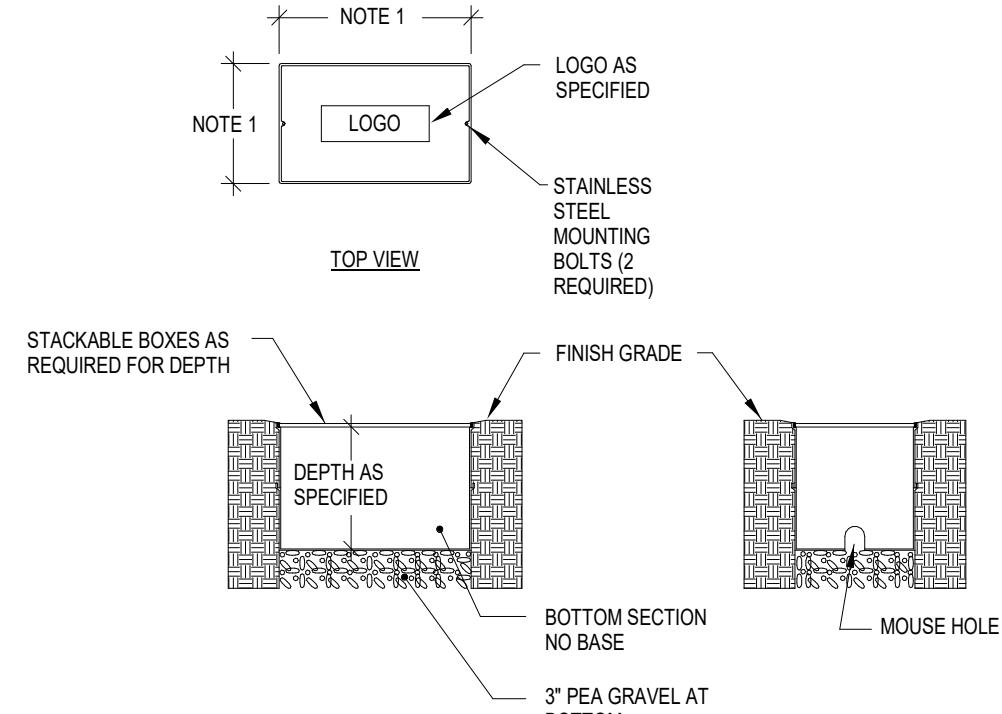

QUAZITE BOX1